


TC BUILDING

GENERAL ARRANGEMENT

The logo consists of a circular emblem containing a stylized letter 'W' or 'M' composed of thick black lines. To the right of the circle, the word 'ERECTION' is written vertically in large, bold, black capital letters. Below it, the words 'N.B. THIS BEAR' and 'RELEVANCE' are stacked in a smaller, regular black font. The entire graphic is set against a white background.

Tel. (02) 9922 2277 Fax. (02) 9957 4197

DATE	07.01.04	PROJECT No.	STATUS
SCALE	AS N.T.S. (B1)	3172	ST/DV
DRAWN			
CHECKED		DWG No.	REV No.
APPROVED		ST400	A

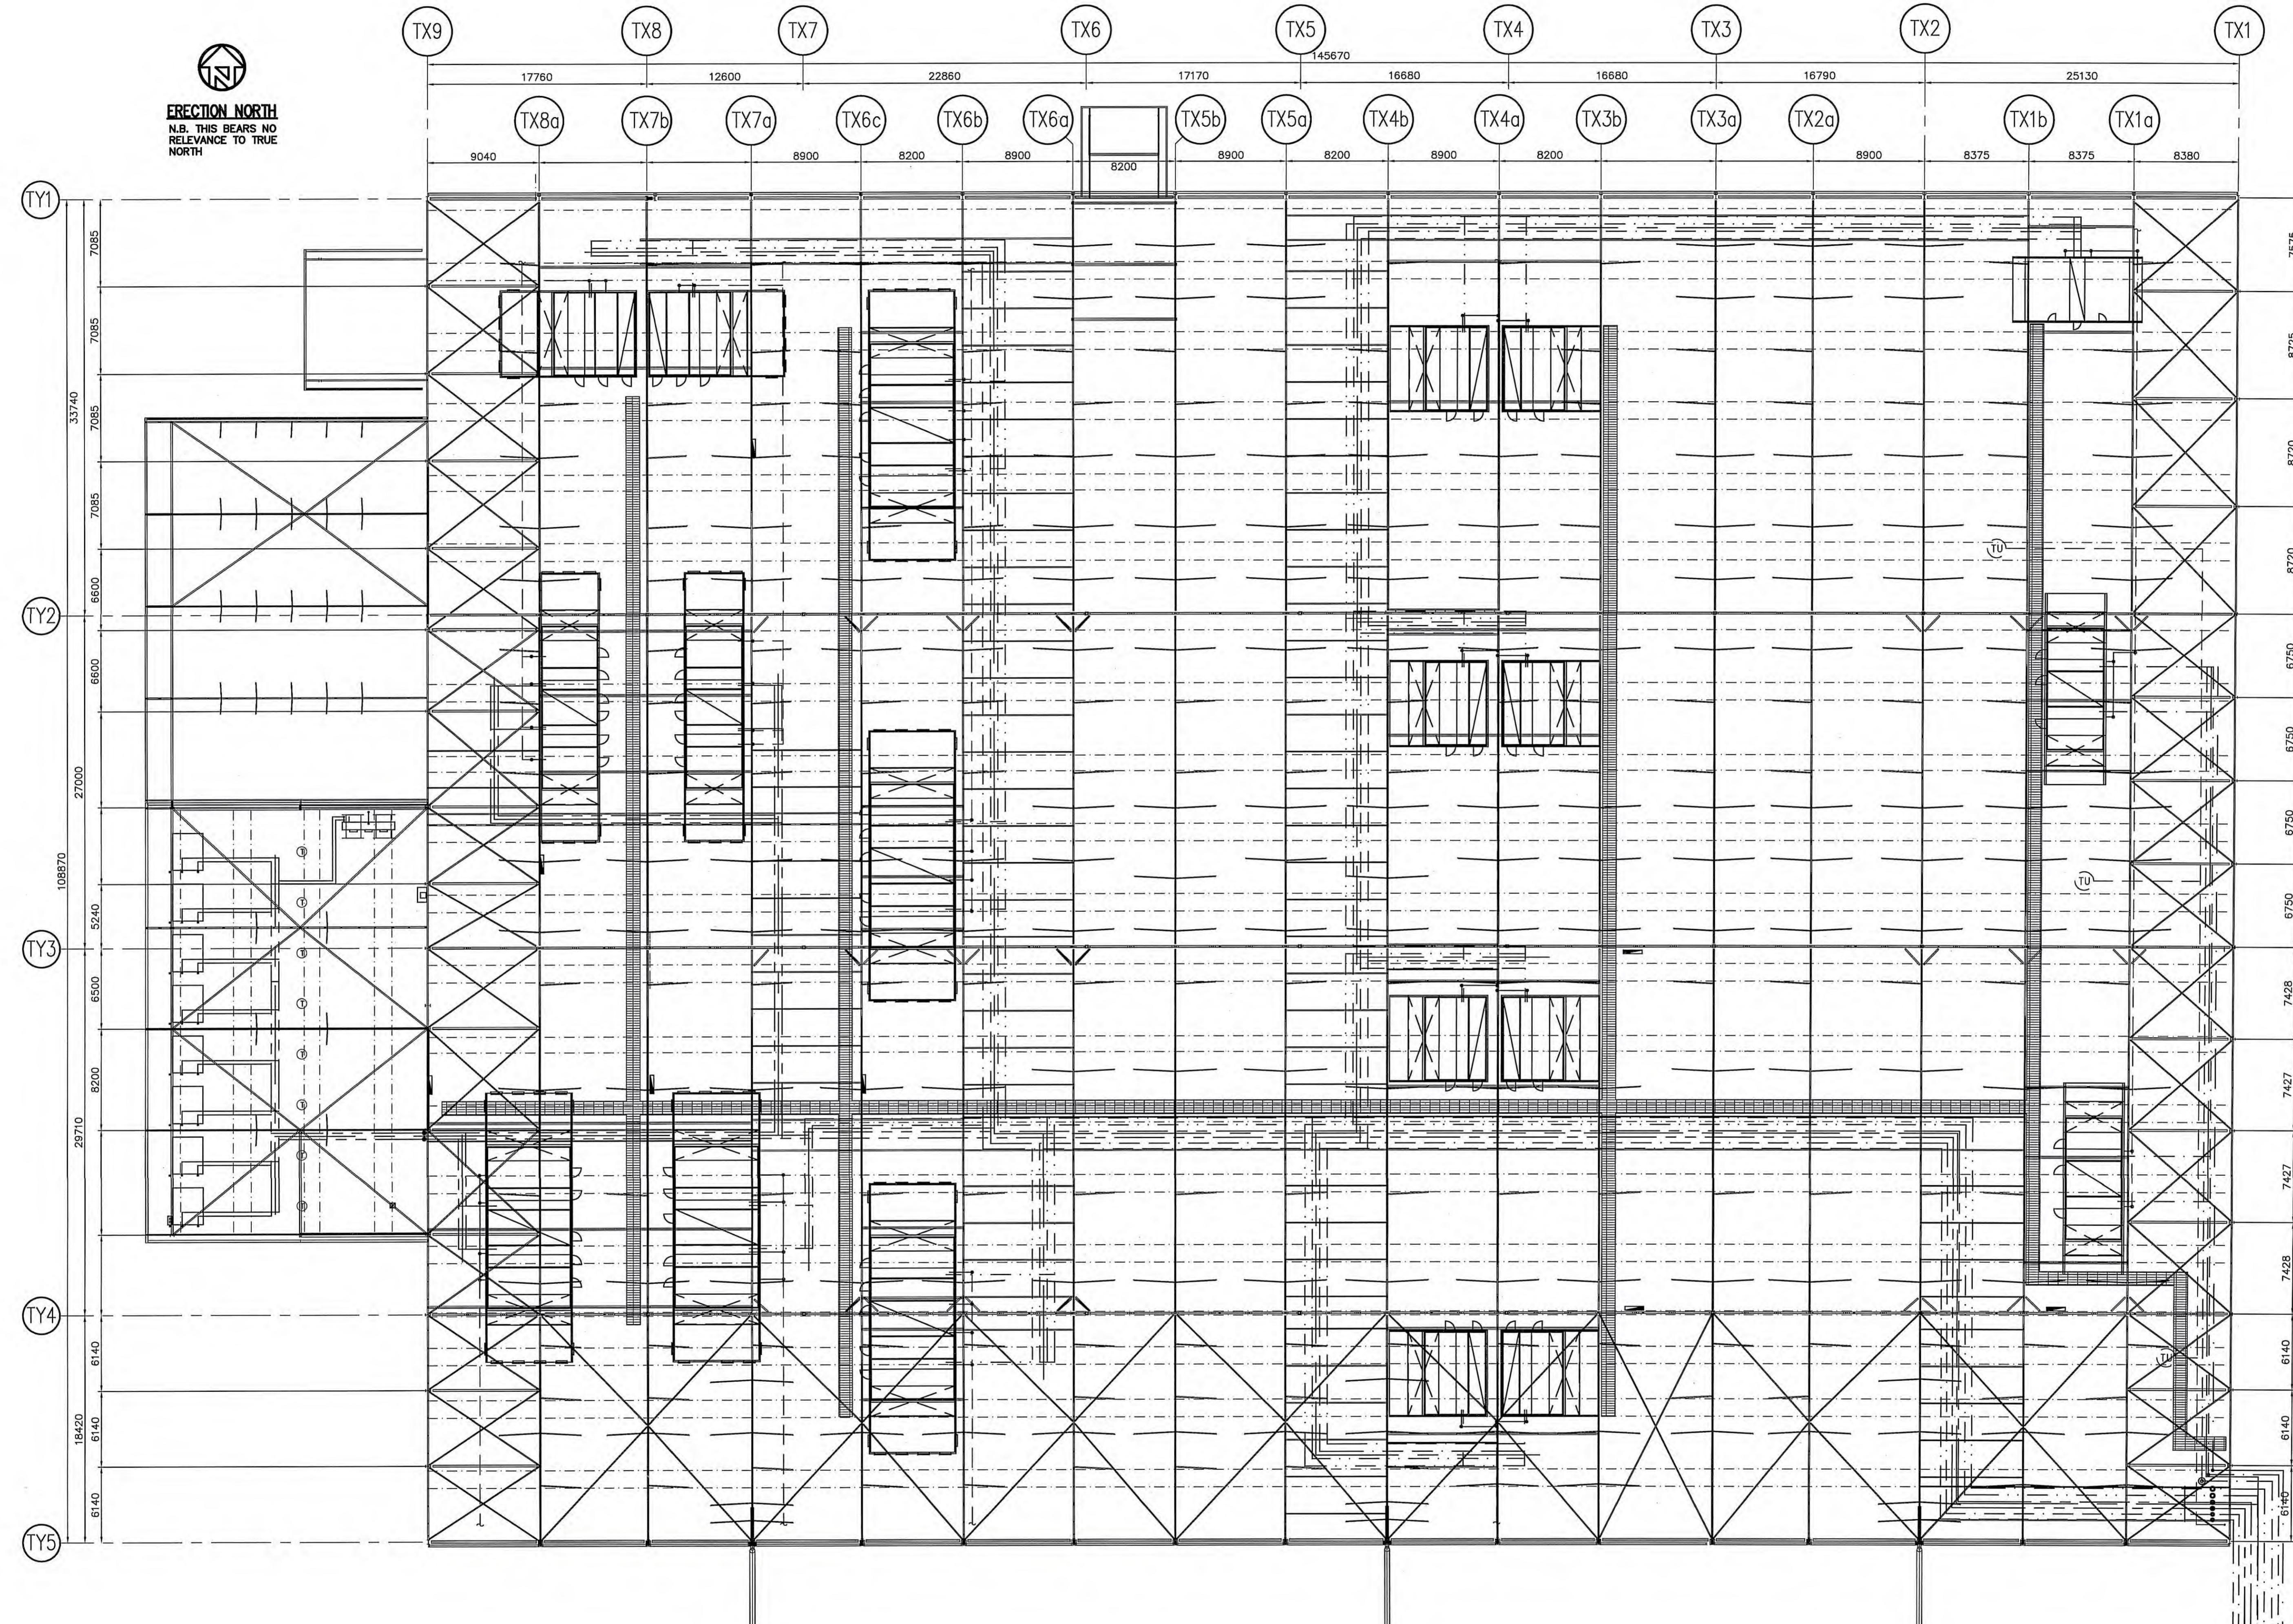


TC BUILDING

ROOF PLANT LAYOUT


TITLE

TC BUILDING

DATE	07.01.04	PROJECT No.	STATUS
SCALE	AS 1:250 (B1)	3172	ST/DV
DRAWN			
CHECKED		DWG No.	REV No.
APPROVED		ST402	A

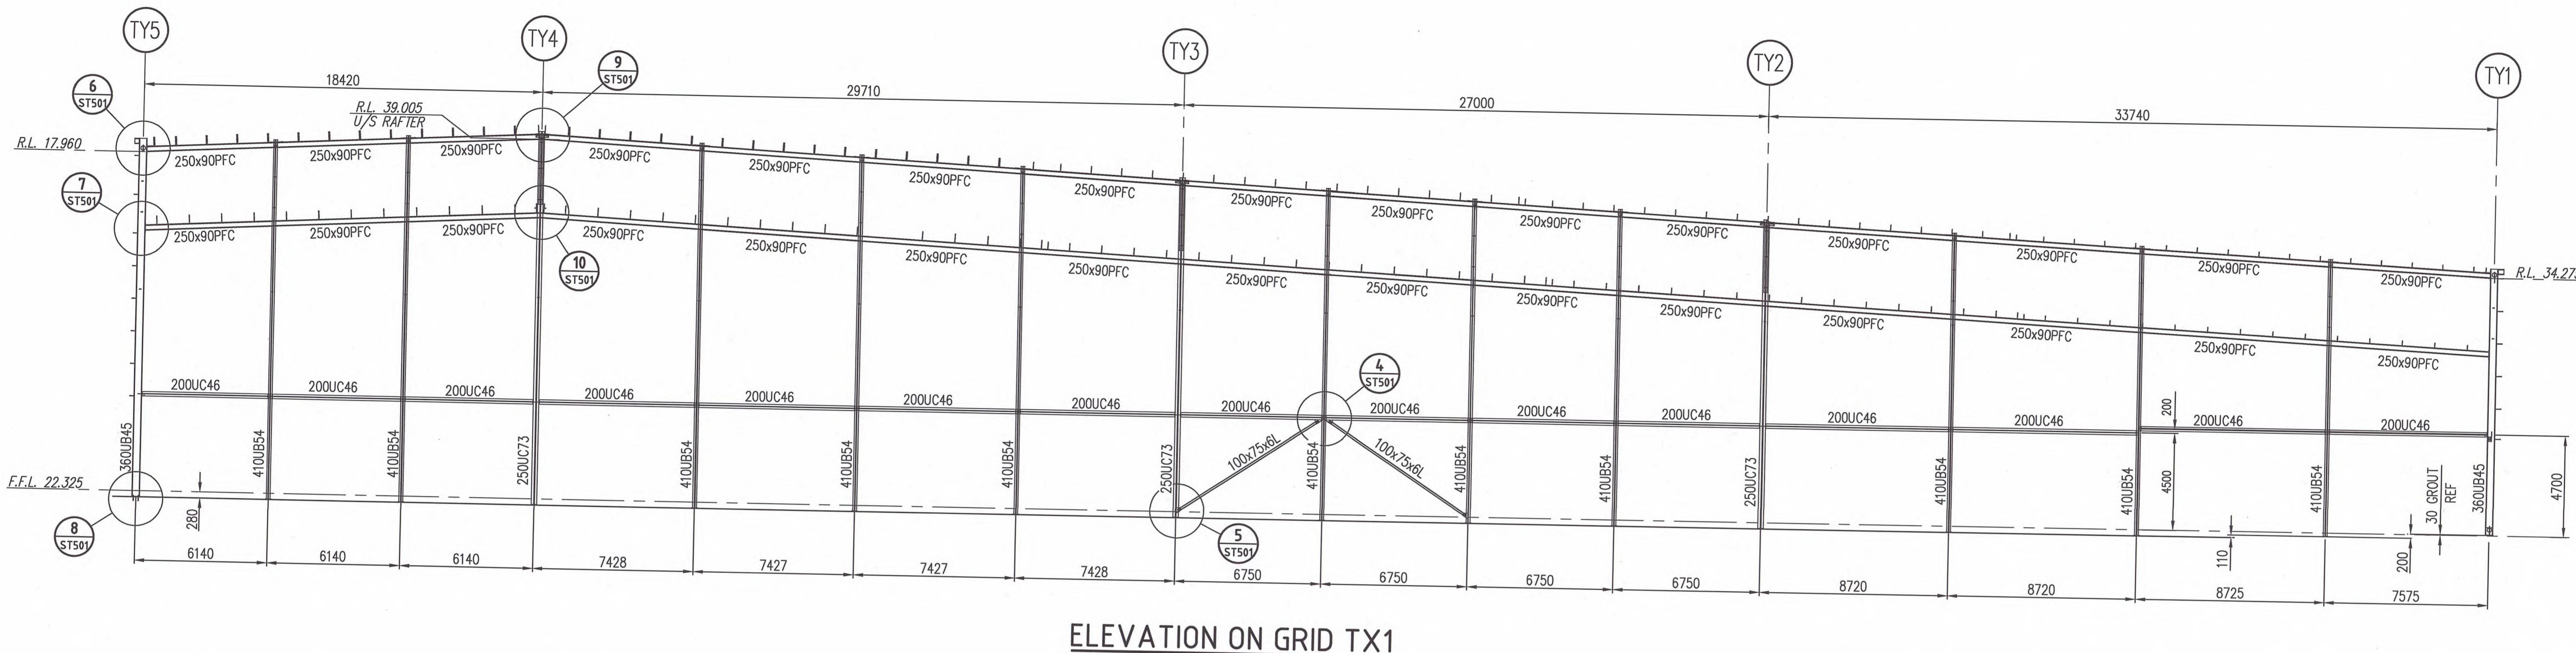

B	02/02/04	MINOR REVISIONS
A	23/01/04	ISSUED FOR DESIGN VERIFICATION
REV. DATE	AMENDMENT	SIGNED
CLIENT		

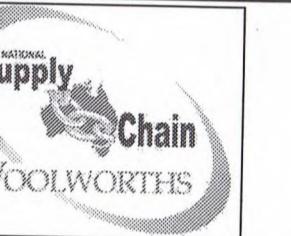

540 George Street
PO Box O70, QVB Post Office
Sydney NSW 2000
Telephone (02) 9323 1555 Facsimile (02) 9323 1595

PROJECT MANAGER
**elifton
coley
stevens**
1st Floor, 59 Subiaco Square, Subiaco, WA 6008
Tel: (08) 9381 6288 Fax: (08) 9381 8277

PROJECT
WOOLWORTHS PERTH RDC
2 HORRIE MILLER DRIVE
PERTH AIRPORT WA 6105

STRUCTURAL, CIVIL & REFRIGERATION ENGINEERS
Beca Pty Ltd
CONSULTING ENGINEERS & PROJECT MANAGERS
Level 5, 20 Charles Street,
Parramatta 2150
Tel: (02) 9891 6773 Fax: (02) 9633 9477
www.beca.com.au

ARCHITECTS
MNIA ARCHITECTS
Level 4, 8 Help Street, Chatswood 2067
Tel: (02) 9495 6400 Fax: (02) 9495 6444

FIRE SERVICES, MECHANICAL & HYDRAULIC ENGINEERS
BASSETT CONSULTING ENGINEERS
Level 12, 132 Arthur Street, North Sydney 2060
Tel: (02) 9957 5577 Fax: (02) 9954 6777

ELECTRICAL ENGINEERS
WOOD & GRIEVE ENGINEERS
933 Ryde Road, Pymble 2073
Tel: (02) 9499 8973 Fax: (02) 9418 4053

FIRE ENGINEERED SOLUTION CONSULTANTS
ARUP
Level 10, 201 Kent Street, Sydney 2000
Tel: (02) 9320 9320 Fax: (02) 9320 9321

ACOUSTIC ENGINEERS
VIPAC ENGINEERS & SCIENTISTS LTD.
25 Paul Street North, North Sydney 2113
Tel: (02) 9805 6000 Fax: (02) 9873 1112

COST MANAGER
RIDER HUNT PTY LTD
41 McLaren Street, North Sydney 2060
Tel: (02) 9922 2277 Fax: (02) 9957 4197

TITLE
TC BUILDING
STRUCTURAL ELEVATIONS
SHEET 1

DATE 15.12.03 PROJECT NO. 3172 STATUS ST/DV

SCALE AS 1:150 (B1)

DRAWN LG. DWG. NO. REV. NO.

CHECKED



APPROVED ST403 B

NOTES:
1. ALL BOLTS TO BRACING TO BE THREADS EXCLUDED.
2. MIN CONNECTION TO BE EX 10 FL CLEAT
2-M20 8.8/S BOLTS
6mm Fw.

B




ELEVATION ON GRID TX9

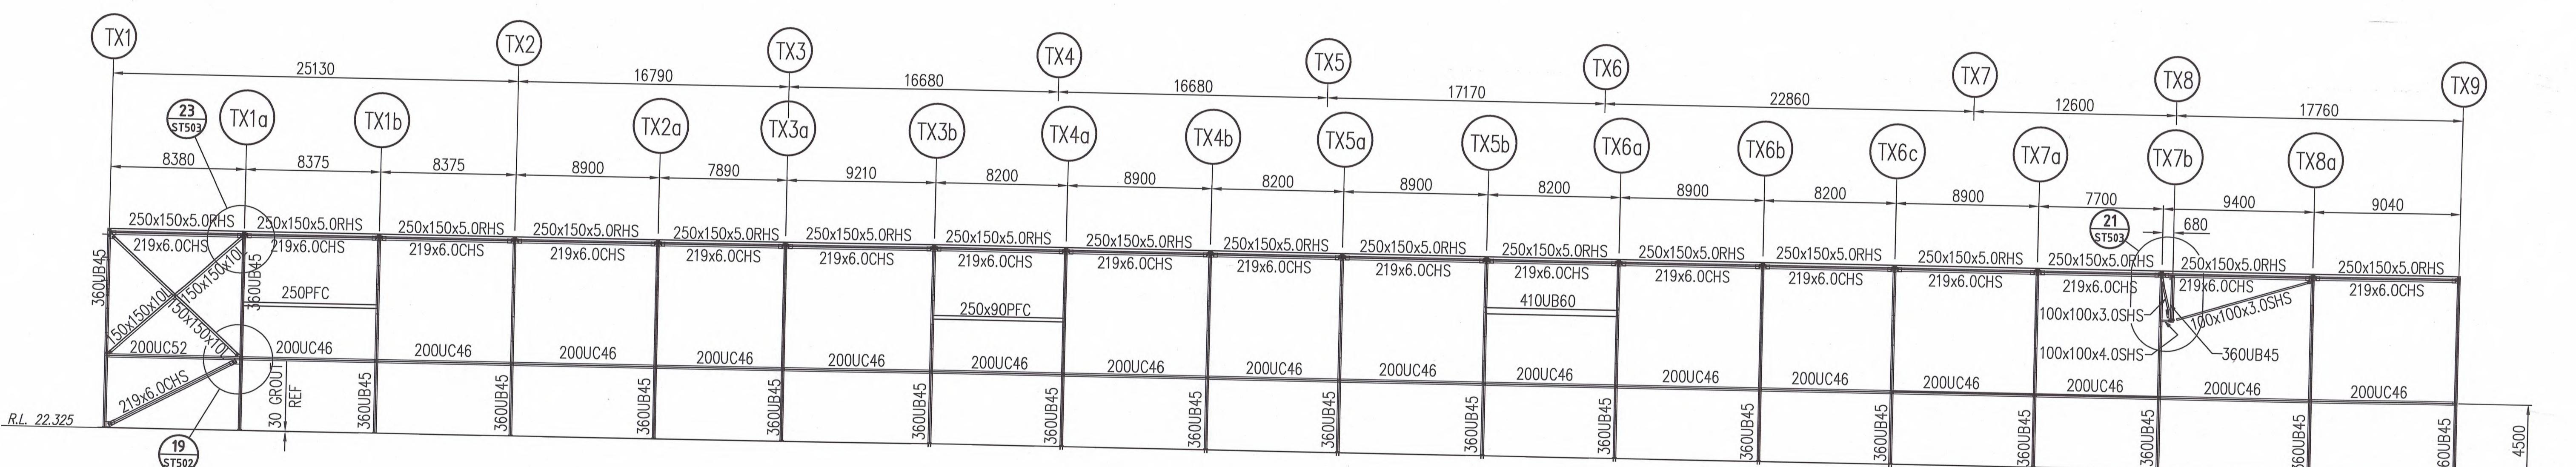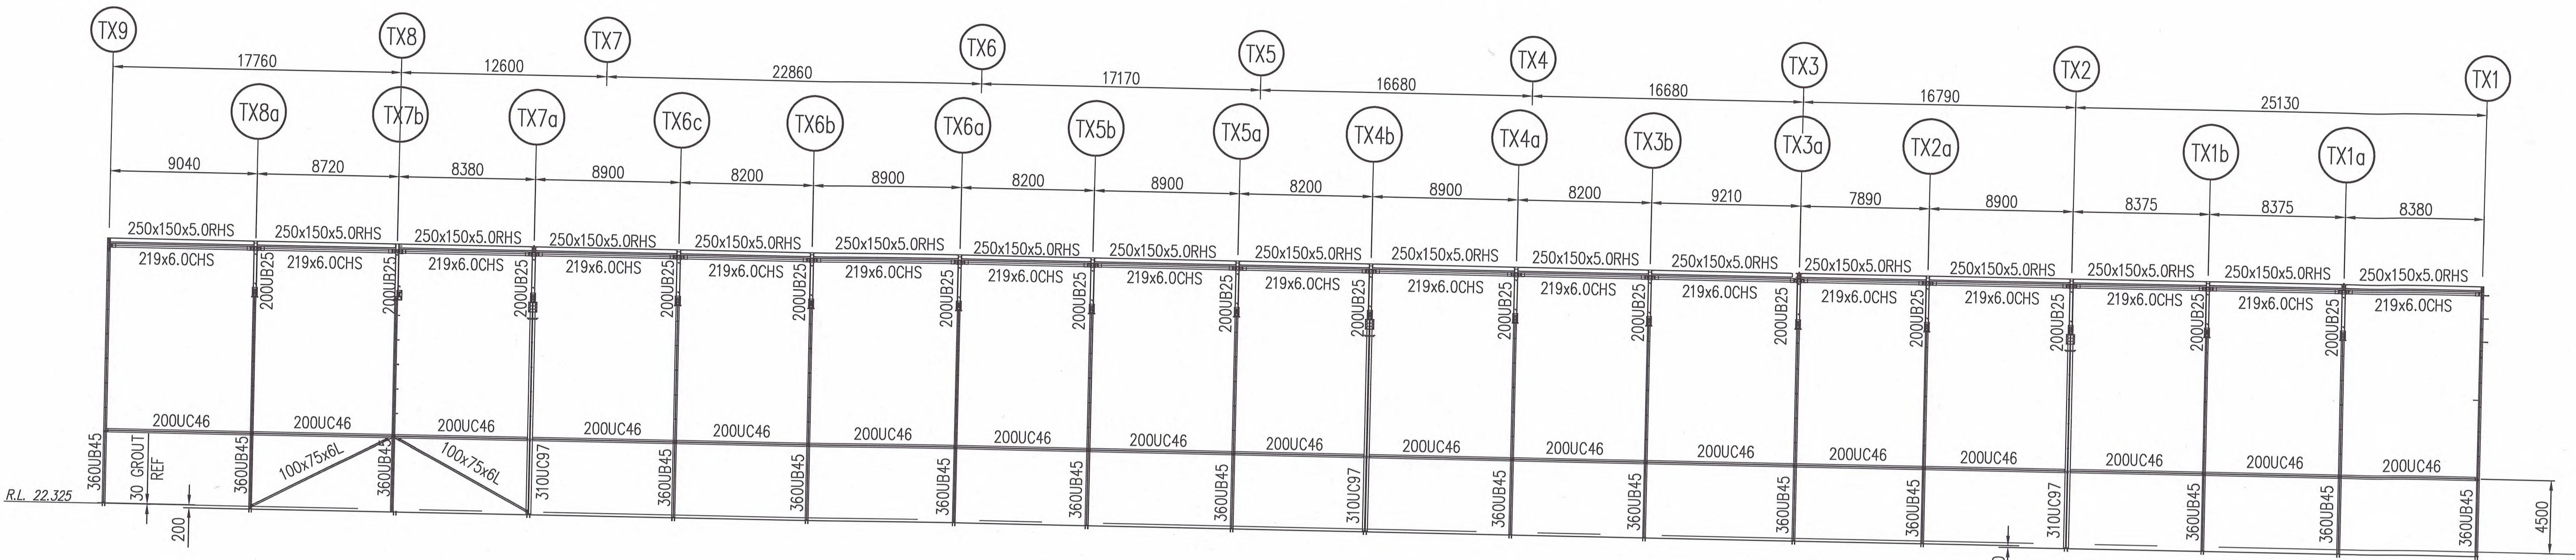


A 23/01/04 ISSUED FOR DESIGN VERIFICATION		REV. DATE:	AMENDMENT:	SIGNED
CLIENT: WOOLWORTHS				
540 George Street PO BOX 070, Old Post Office Telephone (02) 9320 1555 Facsimile (02) 9323 1595				
PROJECT MANAGER: BECIA CONSULTING ENGINEERS & PROJECT MANAGERS Level 5, 20 Charles Street, Parramatta 2150 Tel: (02) 9991 6773 Fax: (02) 9633 9477 www.becia.com.au				
STRUCTURAL, CIVIL & REFRIGERATION ENGINEERS				
ARCHITECTS: MINA ARCHITECTS Level 4, 8 Help Street, Chatswood 2067 Tel: (02) 9495 6400 Fax: (02) 9495 6444				
FIRE SERVICES, MECHANICAL & HYDRAULIC ENGINEERS: BASSETT CONSULTING ENGINEERS Level 12, 12 Arthur Street, North Sydney 2060 Tel: (02) 9957 5577 Fax: (02) 9954 0677				
ELECTRICAL ENGINEERS: WOOD & GRIEVE ENGINEERS 933 Ryde Road, Pymble 2073 Tel: (02) 9499 8973 Fax: (02) 9418 4053				
FIRE ENGINEERED SOLUTION CONSULTANTS: ARUP Level 10, 201 Kent Street, Sydney 2000 Tel: (02) 9320 9320 Fax: (02) 9320 9321				
ACOUSTIC ENGINEERS: VIPAC ENGINEERS & SCIENTISTS LTD. 25 Paul Street North, North Ryde 2113 Tel: (02) 9805 6000 Fax: (02) 9878 1112				
COST MANAGER: RIDER HUNT PTY LTD 41 McLaren Street, North Sydney 2060 Tel: (02) 9222 2277 Fax: (02) 9957 4197				
TITLE: TC BUILDING STRUCTURAL ELEVATION S SHEET 2				
DATE: 07/01/04	PROJECT NO.: 3172	STATUS: ST/D		
SCALE: AS 1:50 (B1)				
DRAWN:				
CHECKED:				
APPROVED:				

ST404 A

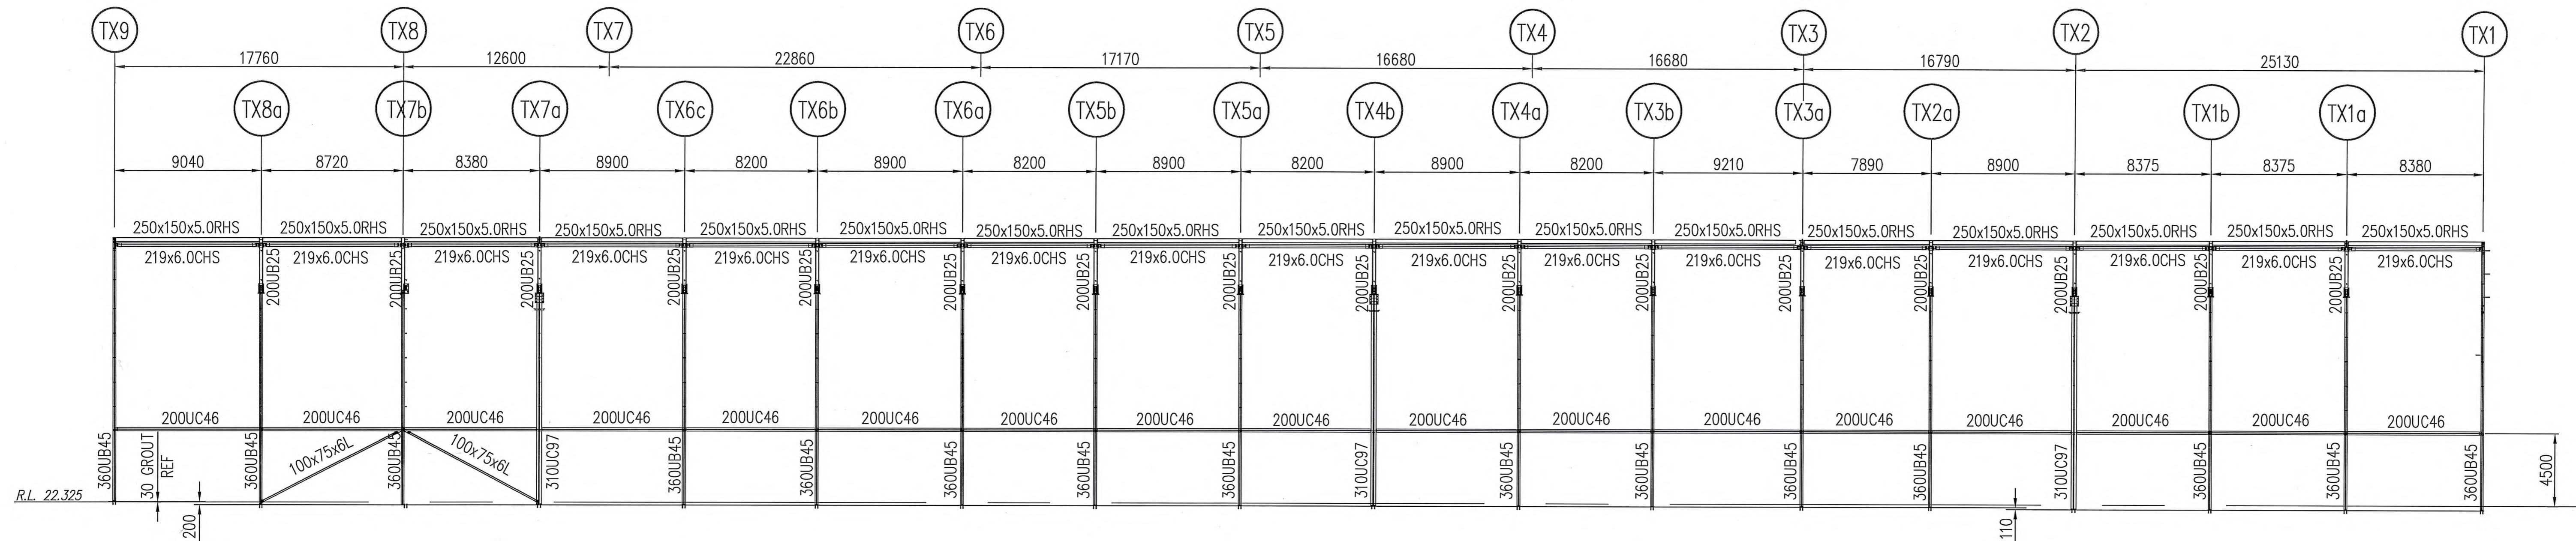

EL E V A T I O N O N G R I D T Y 5

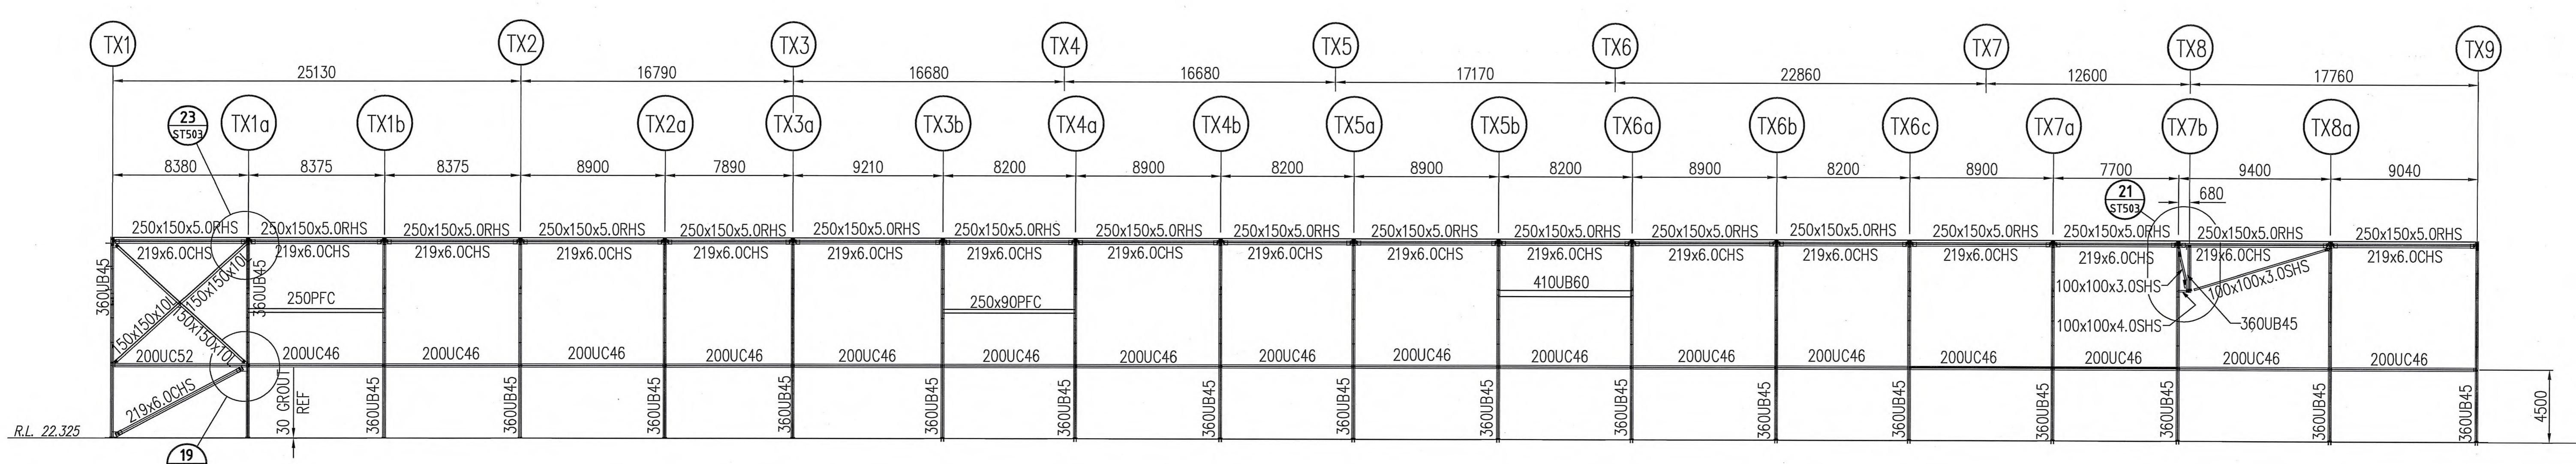

ELEVATION ON GRID TY1

A 23/01/04 ISSUED FOR DESIGN VERIFICATION

REV. DATE AMENDMENT

SIGNED

CLIENT

540 George Street Sydney NSW 2000
 PO BOX Q70, QVB Post Office Sydney NSW 1230
 Telephone (02) 9323 1555 Facsimile (02) 9323 1595

PROJECT MANAGER

**clifton
coney
stevens**

1st Floor, 50 Subiaco Square, Subiaco, WA 6008
 Tel: (08) 9381 6288 Fax: (08) 9381 6277

PROJECT

WOOLWORTHS PERTH RDC
2 HORRIE MILLER DRIVE
PERTH AIRPORT WA 6105

STRUCTURAL, CIVIL & REFRIGERATION ENGINEERS

Beca Pty Ltd

CONSULTING ENGINEERS & PROJECT MANAGERS
 Level 5, 20 Charles Street,
 Parramatta 2150
 Tel. (02) 9891 6773 Fax. (02) 9633 9477
www.beca.com.au

ARCHITECTS

MNIA ARCHITECTS

Level 4, 8 Help Street, Chatswood 2067
 Tel: (02) 9495 6400 Fax: (02) 9495 6444

FIRE SERVICES, MECHANICAL & HYDRAULIC ENGINEERS

BASSETT CONSULTING ENGINEERS

Level 12, 132 Arthur Street, North Sydney 2060
 Tel: (02) 9957 5577 Fax: (02) 9954 0677

ELECTRICAL ENGINEERS

WOOD & GRIEVE ENGINEERS

9/33 Ryde Road, Pymble 2073
 Tel: (02) 9499 8973 Fax: (02) 9418 4053

FIRE ENGINEERED SOLUTION CONSULTANTS

ARUP

Level 10, 201 Kent Street, Sydney 2000
 Tel: (02) 9320 9320 Fax: (02) 9320 9321

ACOUSTIC ENGINEERS

VIPAC ENGINEERS & SCIENTISTS LTD.

25 Paul Street North, North Ryde 2113
 Tel: (02) 9805 6000 Fax: (02) 9878 1112


COST MANAGER

RIDER HUNT PTY LTD


41 McLaren Street, North Sydney 2060

Tel: (02) 9222 2277 Fax: (02) 9257 4407

TITLE			
TC BUILDING STRUCTURAL ELEVATIONS SHEET 2			
DATE	07.01.04	PROJECT No.	STATUS
SCALE	AS 1:150	(B1)	3172 ST/DV
DRAWN			
CHECKED			
APPROVED			
		DWG No.	REV No.
		ST404	A

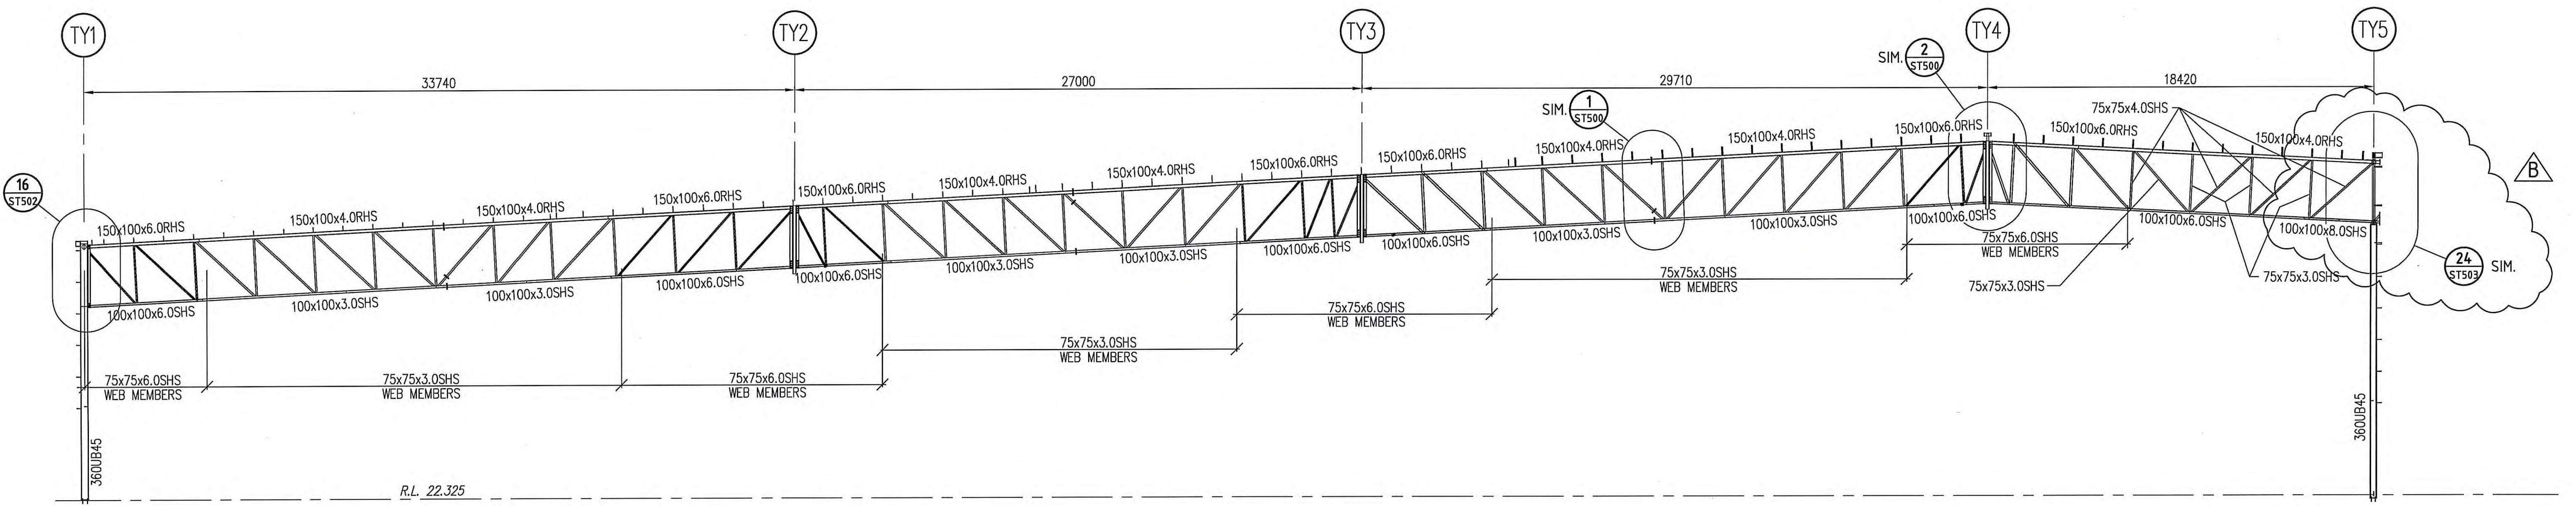


SECTION ON STANDARD TRUSS

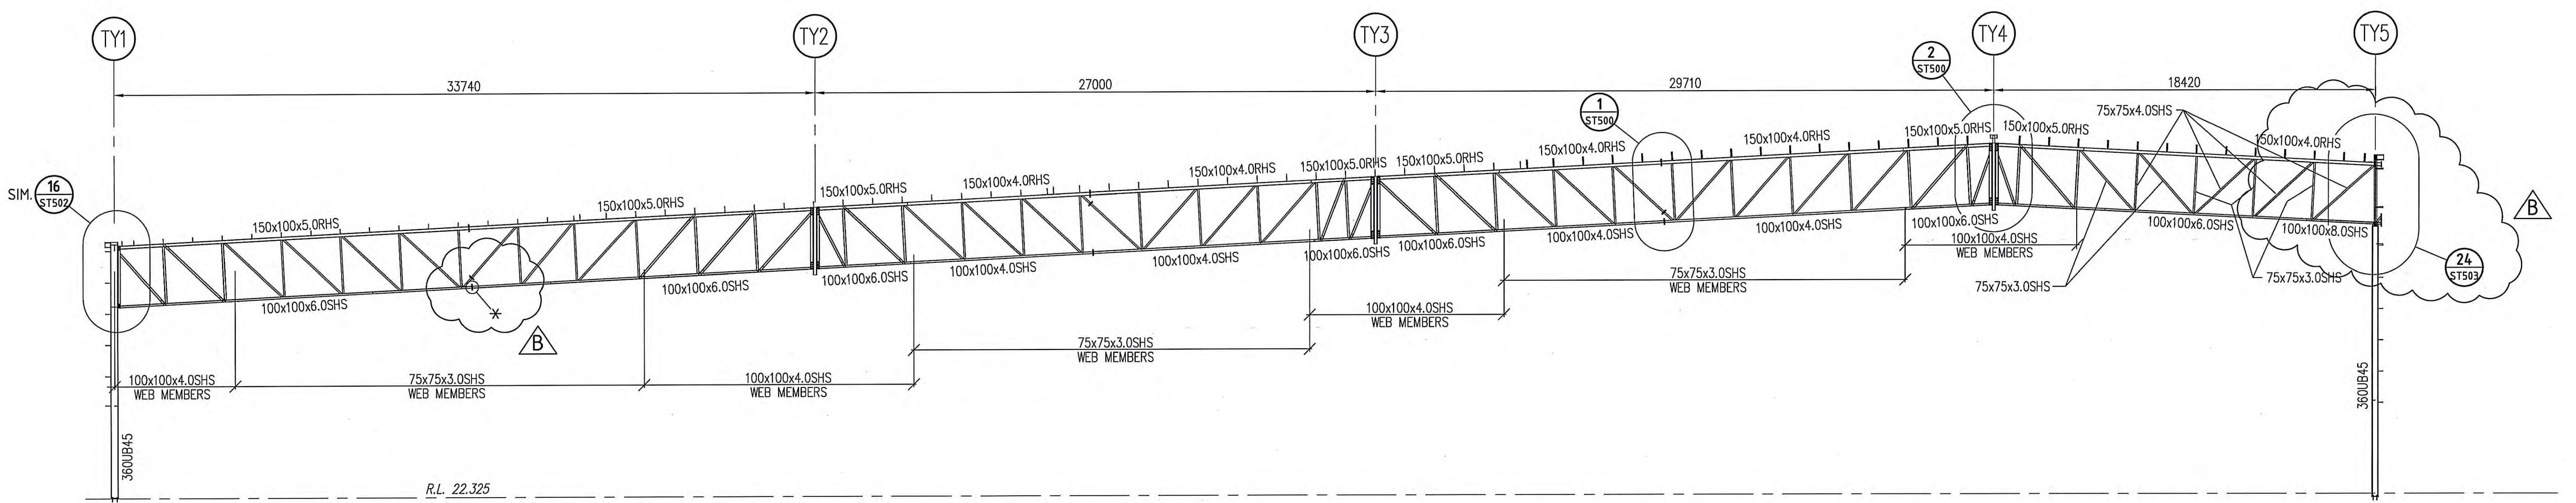


NOTE:
TRUSS CHORD SPLICED
DENOTED THUS * TO HAVE
EX 200x25PL CONNECTION

SECTION ON HEAVY DUTY TRUSS

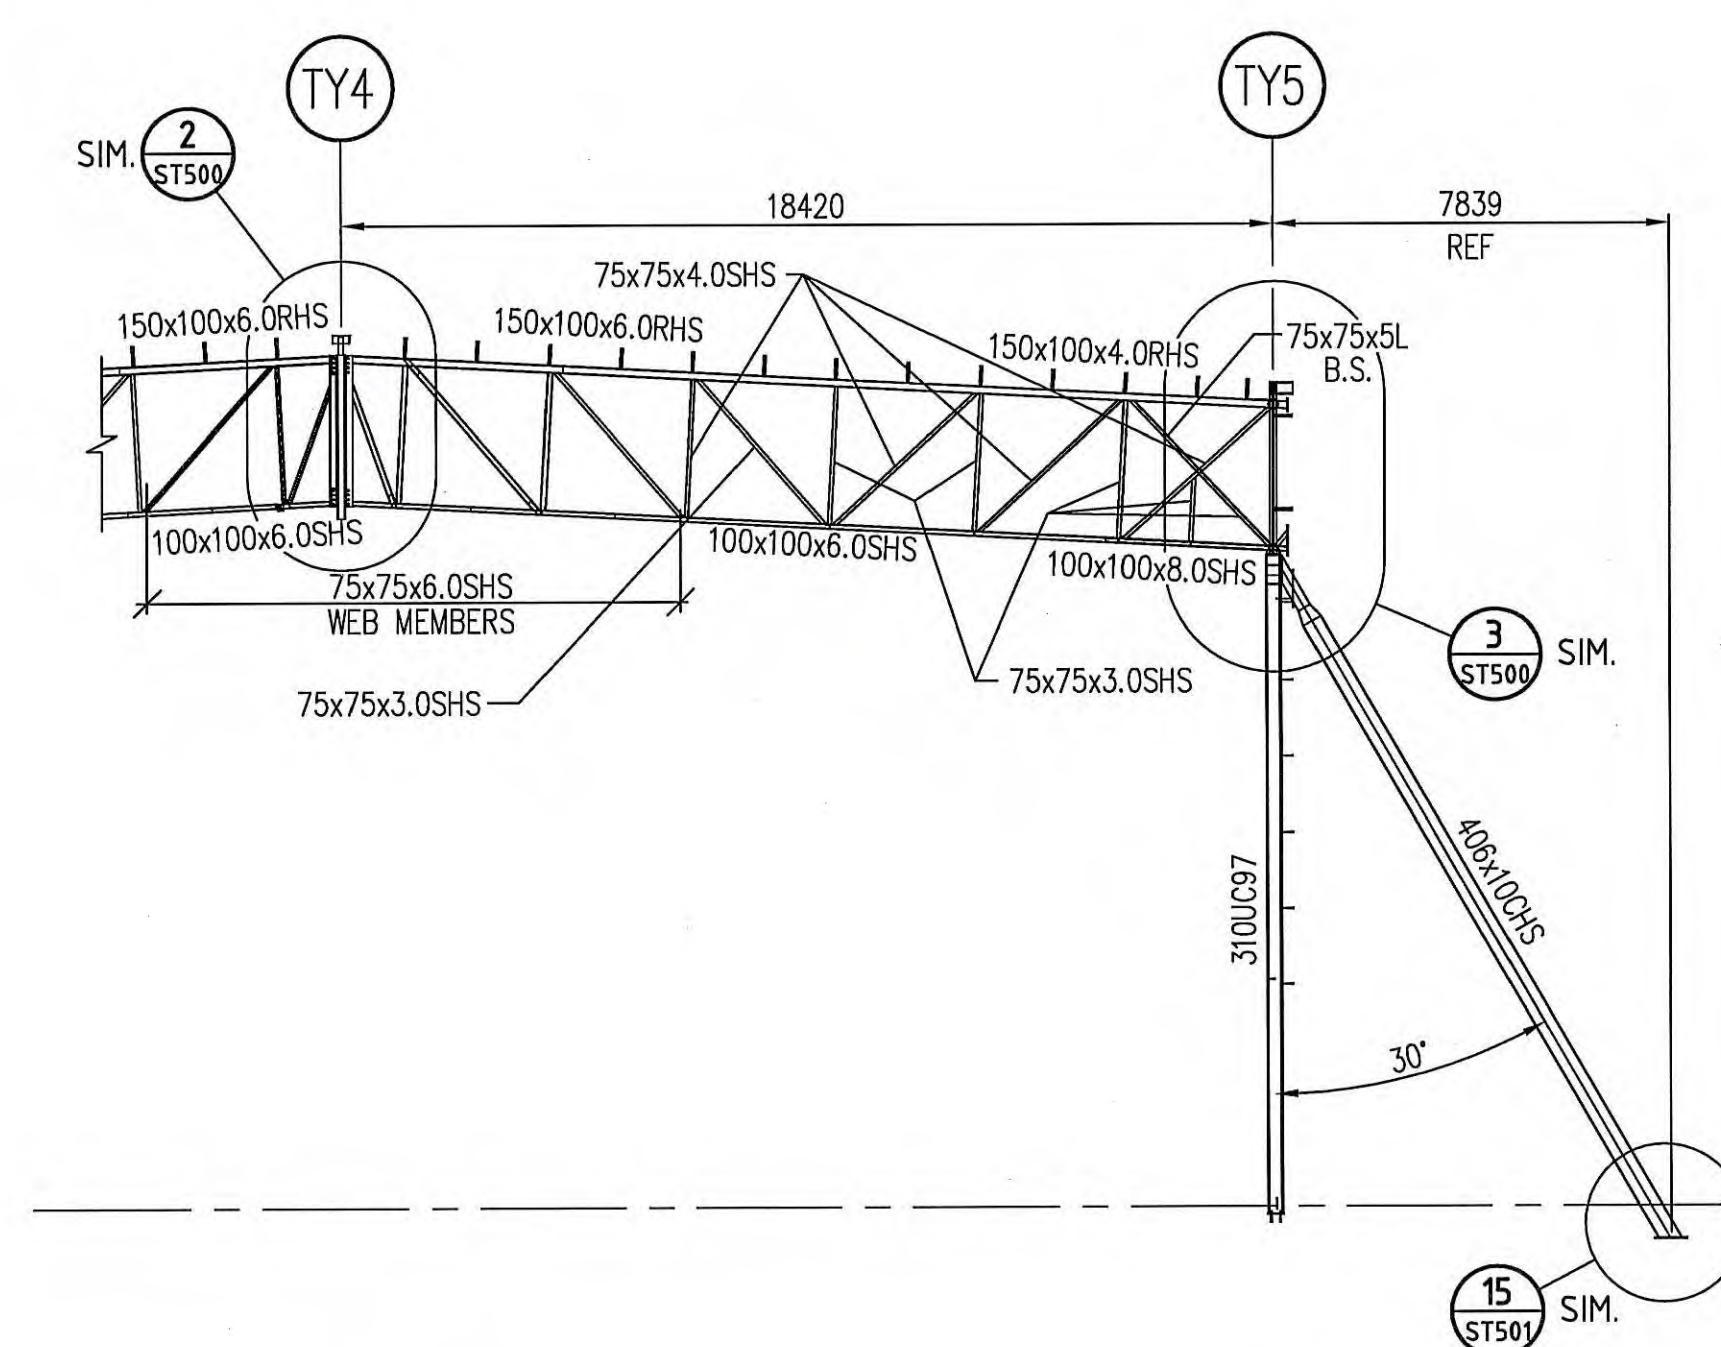

PART SECTION ON STANDARD TRUSS
AT HAUNCH LOCATION

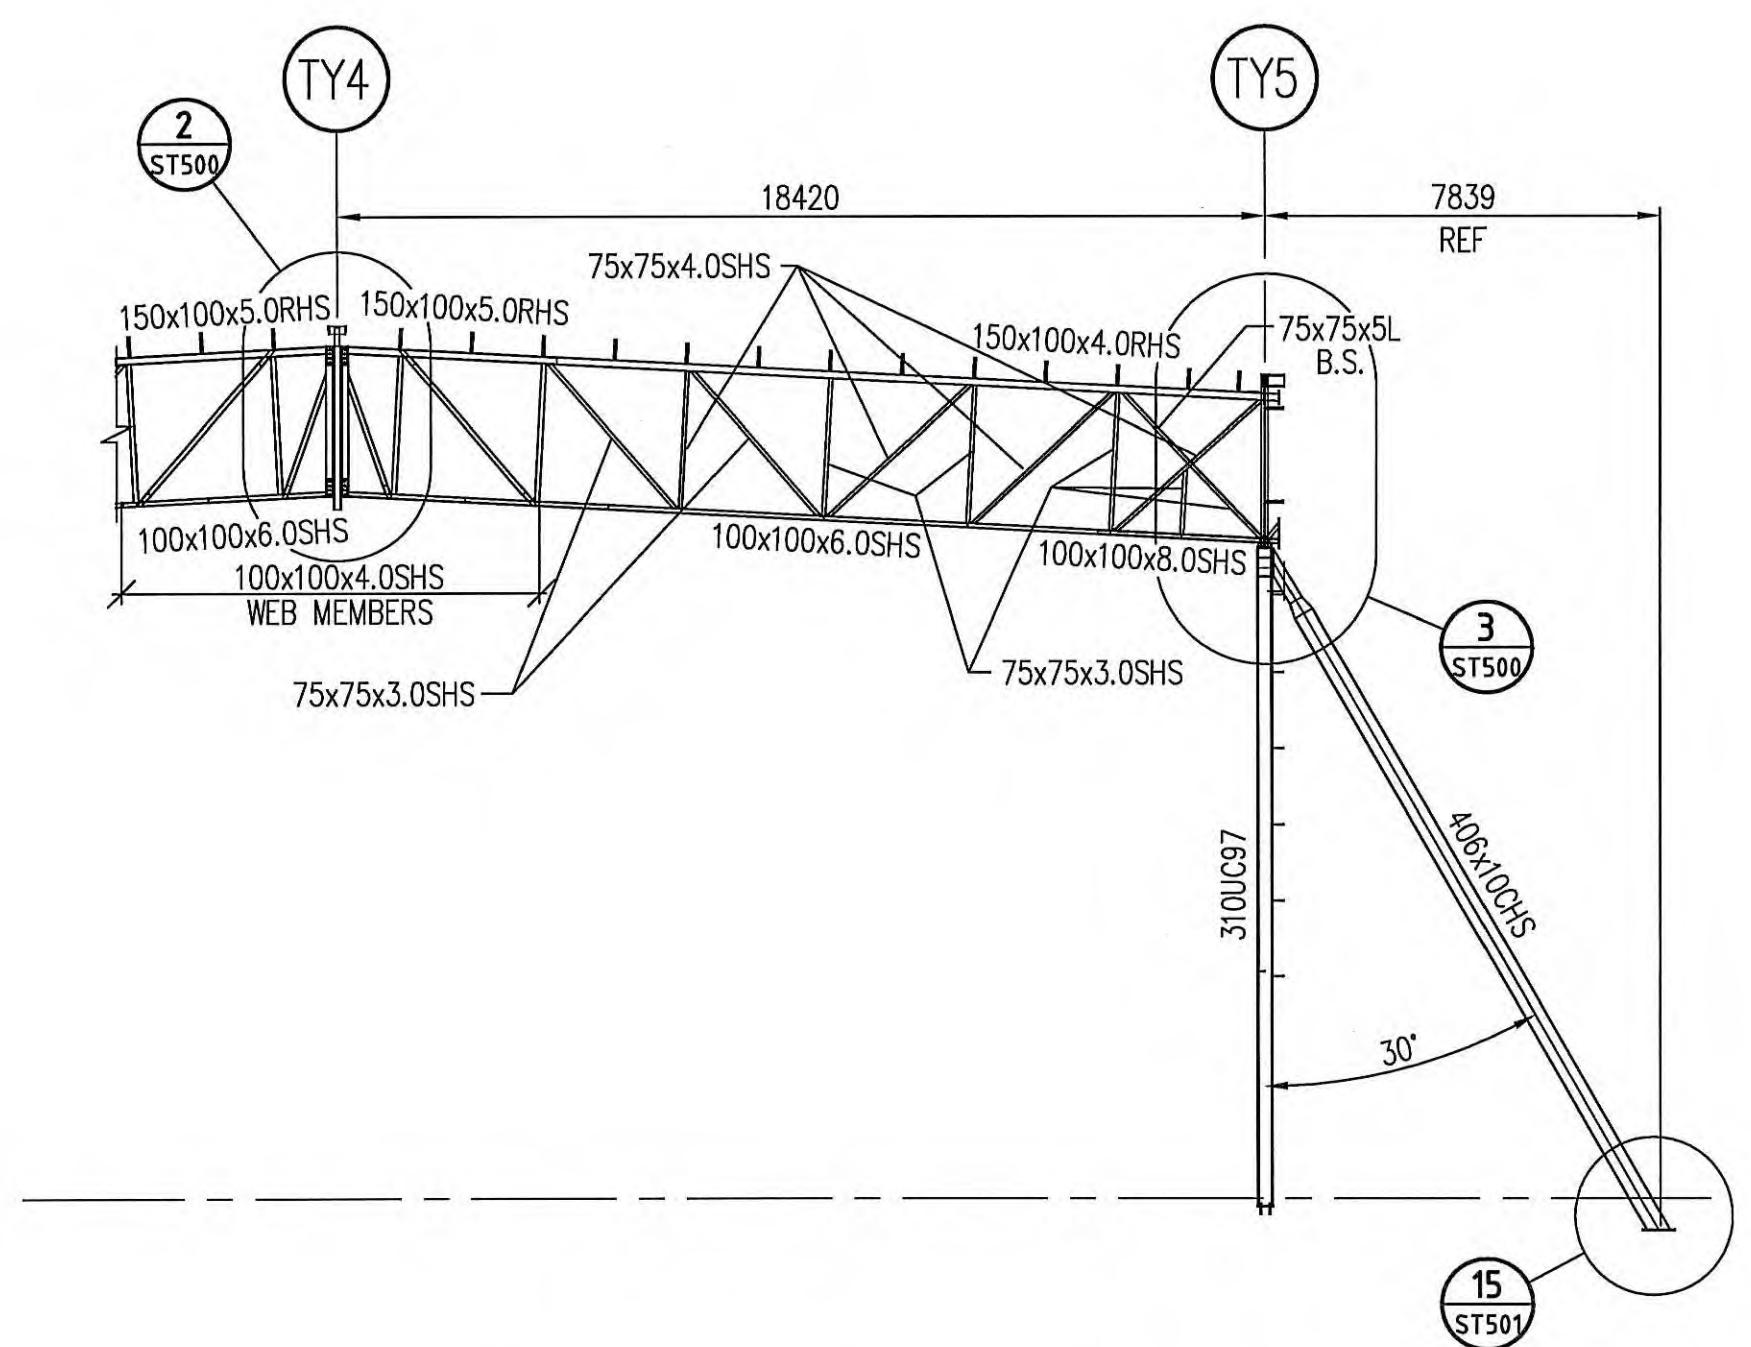

PART SECTION ON HEAVY DUTY TRUSS
AT HAUNCH LOCATION

B 02/02/04 MINOR REVISIONS
A 23/01/04 ISSUED FOR DESIGN VERIFICATION
REV. DATE AMENDMENT SIGNED
CLIENT
 Supply Chain WOOLWORTHS
54 George Street
PO Box C70, QVB Post Office
Telephone (02) 9323 1555 Facsimile (02) 9323 1555

PROJECT MANAGER
 clifton stevens
1st Floor, 51 Subiaco Square, Subiaco, WA 6008
Tel: (08) 9381 5288 Fax: (08) 9381 6277

PROJECT
WOOLWORTHS PERTH RDC
2 HORRIE MILLER DRIVE
PERTH AIRPORT WA 6105

STRUCTURAL, CIVIL & REFRIGERATION ENGINEERS
 Beca Pty Ltd
Level 5, 20 Charles Street,
Parramatta 2150
Tel. (02) 9891 6773 Fax. (02) 9833 9477
www.beca.com.au

ARCHITECTS
 MNA ARCHITECTS
Level 4, 8 Help Street, Chatswood 2067
Tel: (02) 9495 6400 Fax: (02) 9495 6444

FIRE SERVICES, MECHANICAL & HYDRAULIC ENGINEERS
 BASSETT CONSULTING ENGINEERS
Level 12, 132 Arthur Street, North Sydney 2060
Tel: (02) 9957 5577 Fax: (02) 9954 0677

ELECTRICAL ENGINEERS
 WOOD & GRIEVE ENGINEERS
933 Ryde Road, Rydale 2073
Tel: (02) 9499 8972 Fax: (02) 9418 4053


FIRE ENGINEERED SOLUTIONS CONSULTANTS
 ARUP
Level 10, 201 Kent Street, Sydney 2000
Tel: (02) 9320 9320 Fax: (02) 9320 9321


ACOUSTIC ENGINEERS
 VIPAC ENGINEERS & SCIENTISTS LTD.
25 Paul Street North, North Ryde 2113
Tel: (02) 9895 6000 Fax: (02) 9879 1112

COST MANAGER
 RIDER HUNT PTY LTD
41 McLaren Street, North Sydney 2000
Tel: (02) 9922 2277 Fax: (02) 9957 4197


TITLE
TC BUILDING
STRUCTURAL SECTIONS
SHEET 2

DATE 07.01.04 PROJECT NO. 3172 ST/DV
SCALE AS 1:250 (B1)
DRAWN
CHECKED DWG No.
APPROVED ST406 B

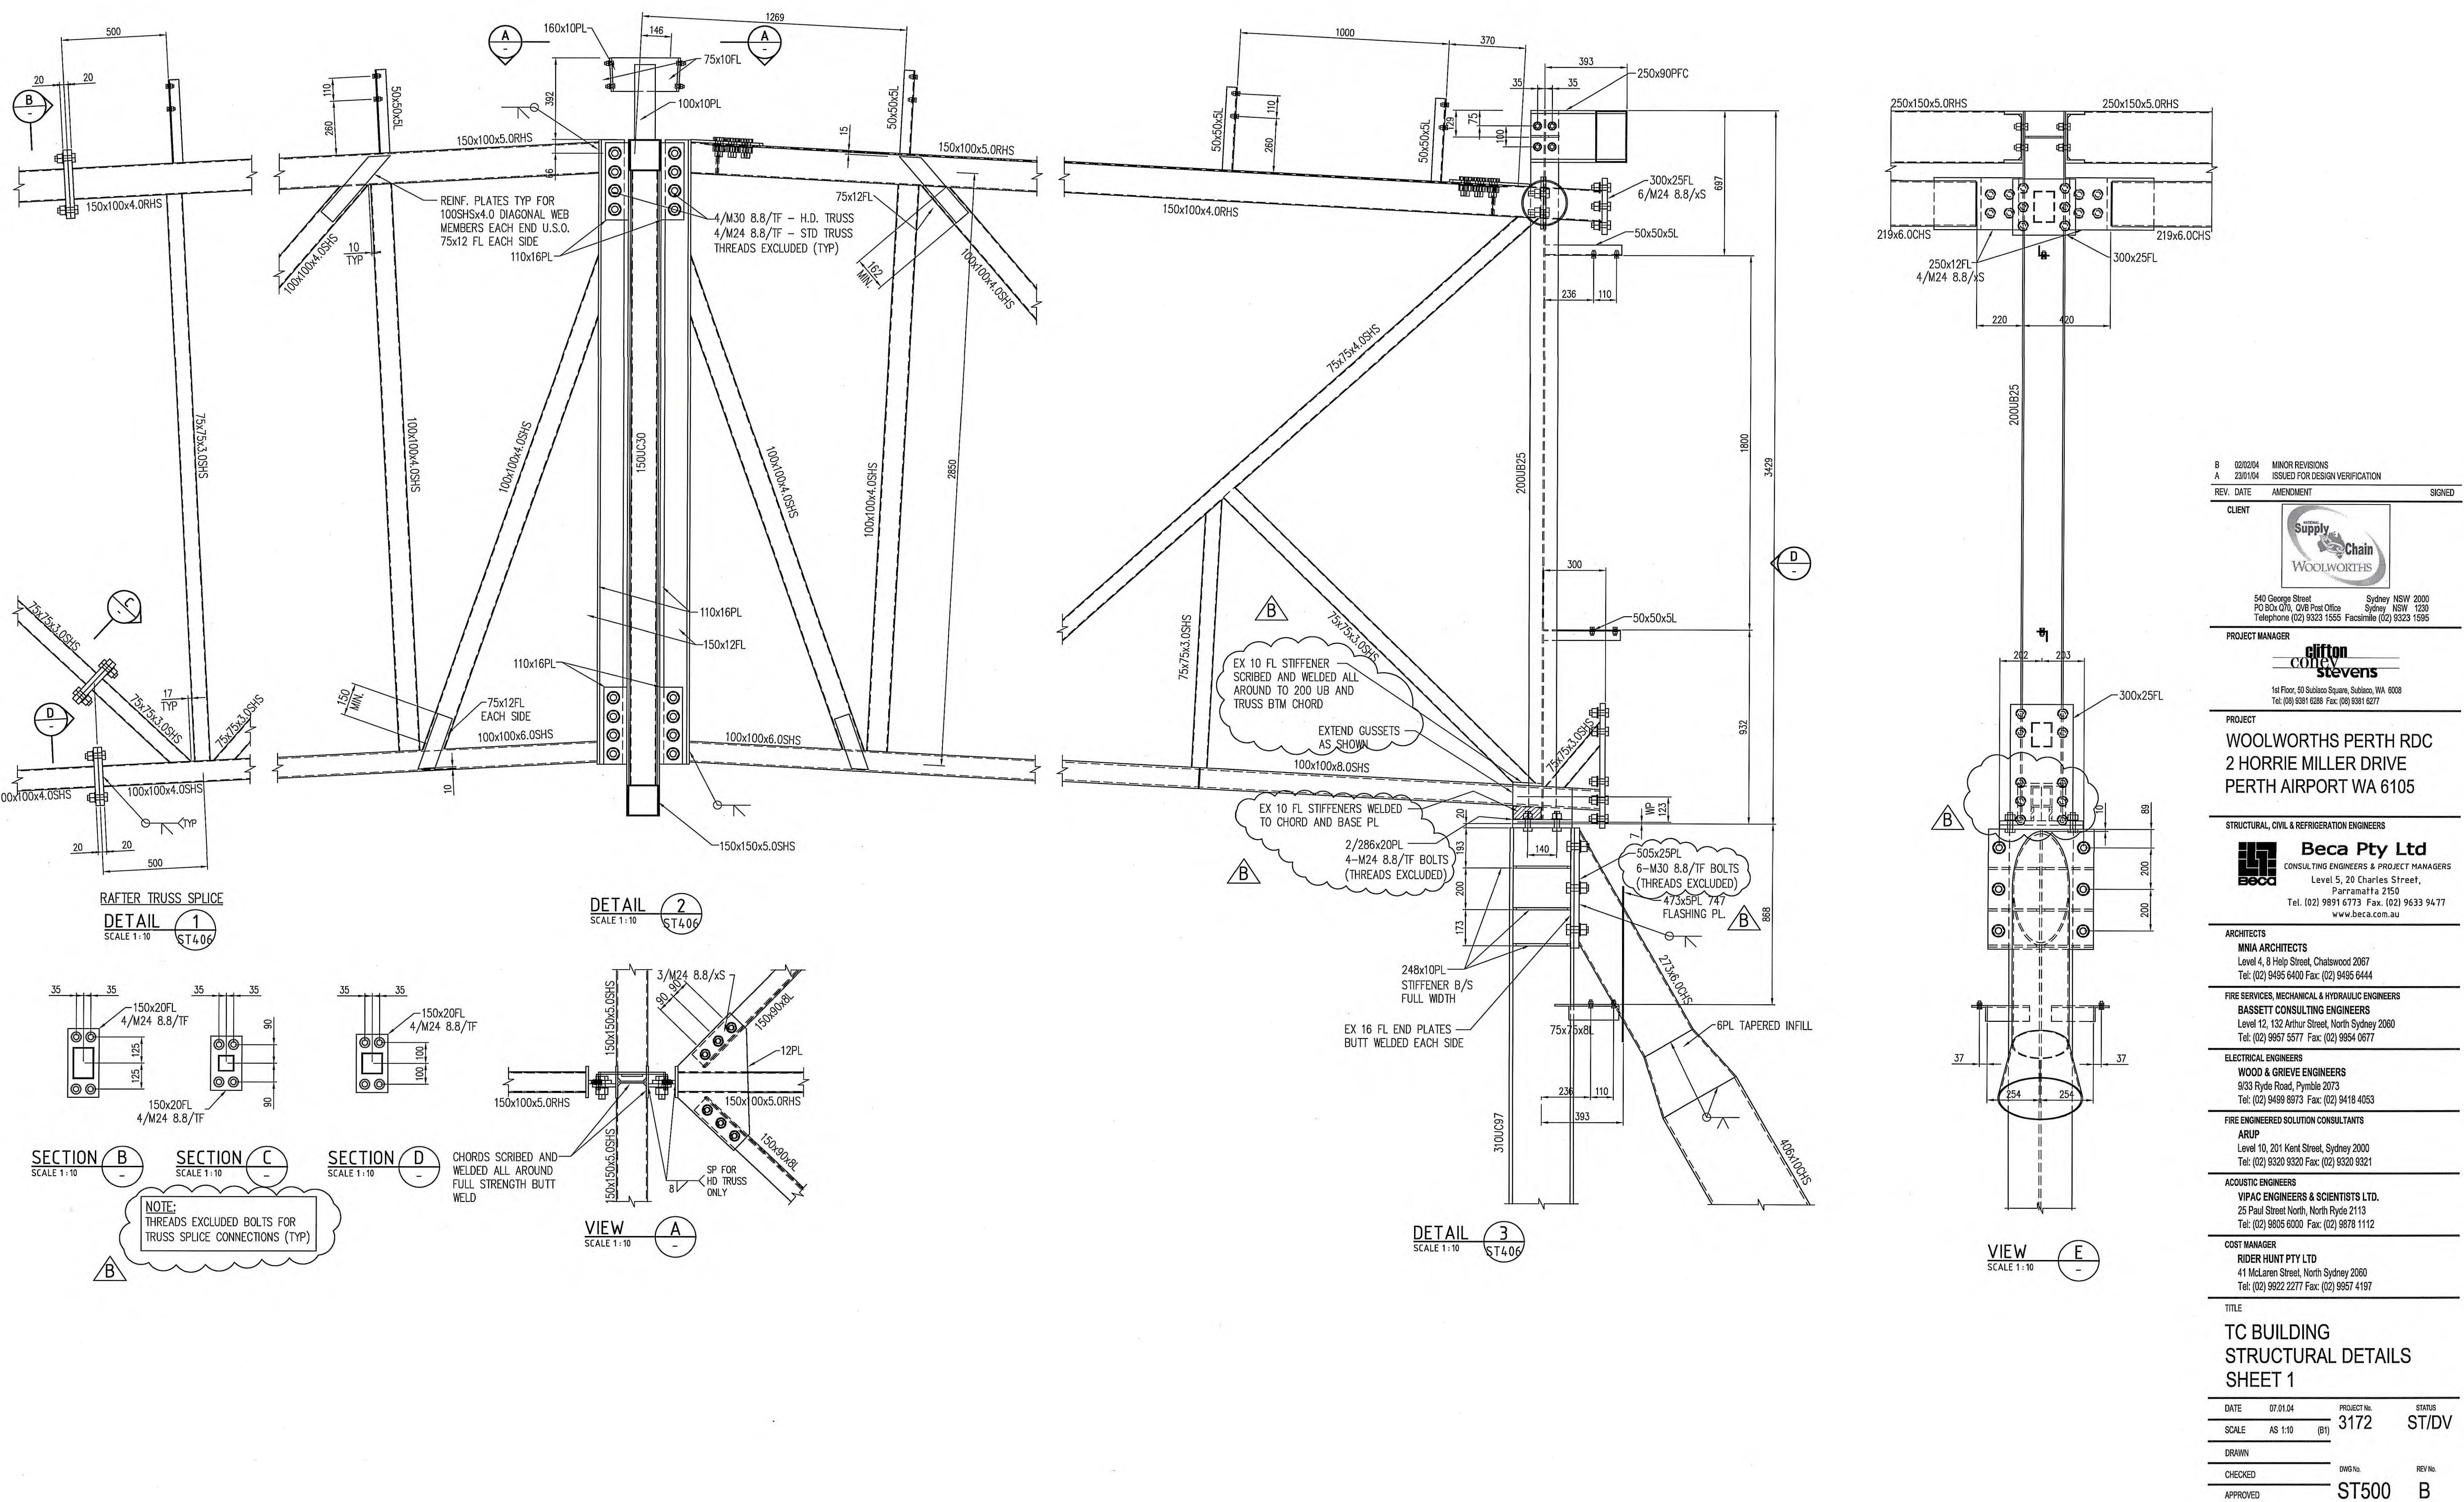

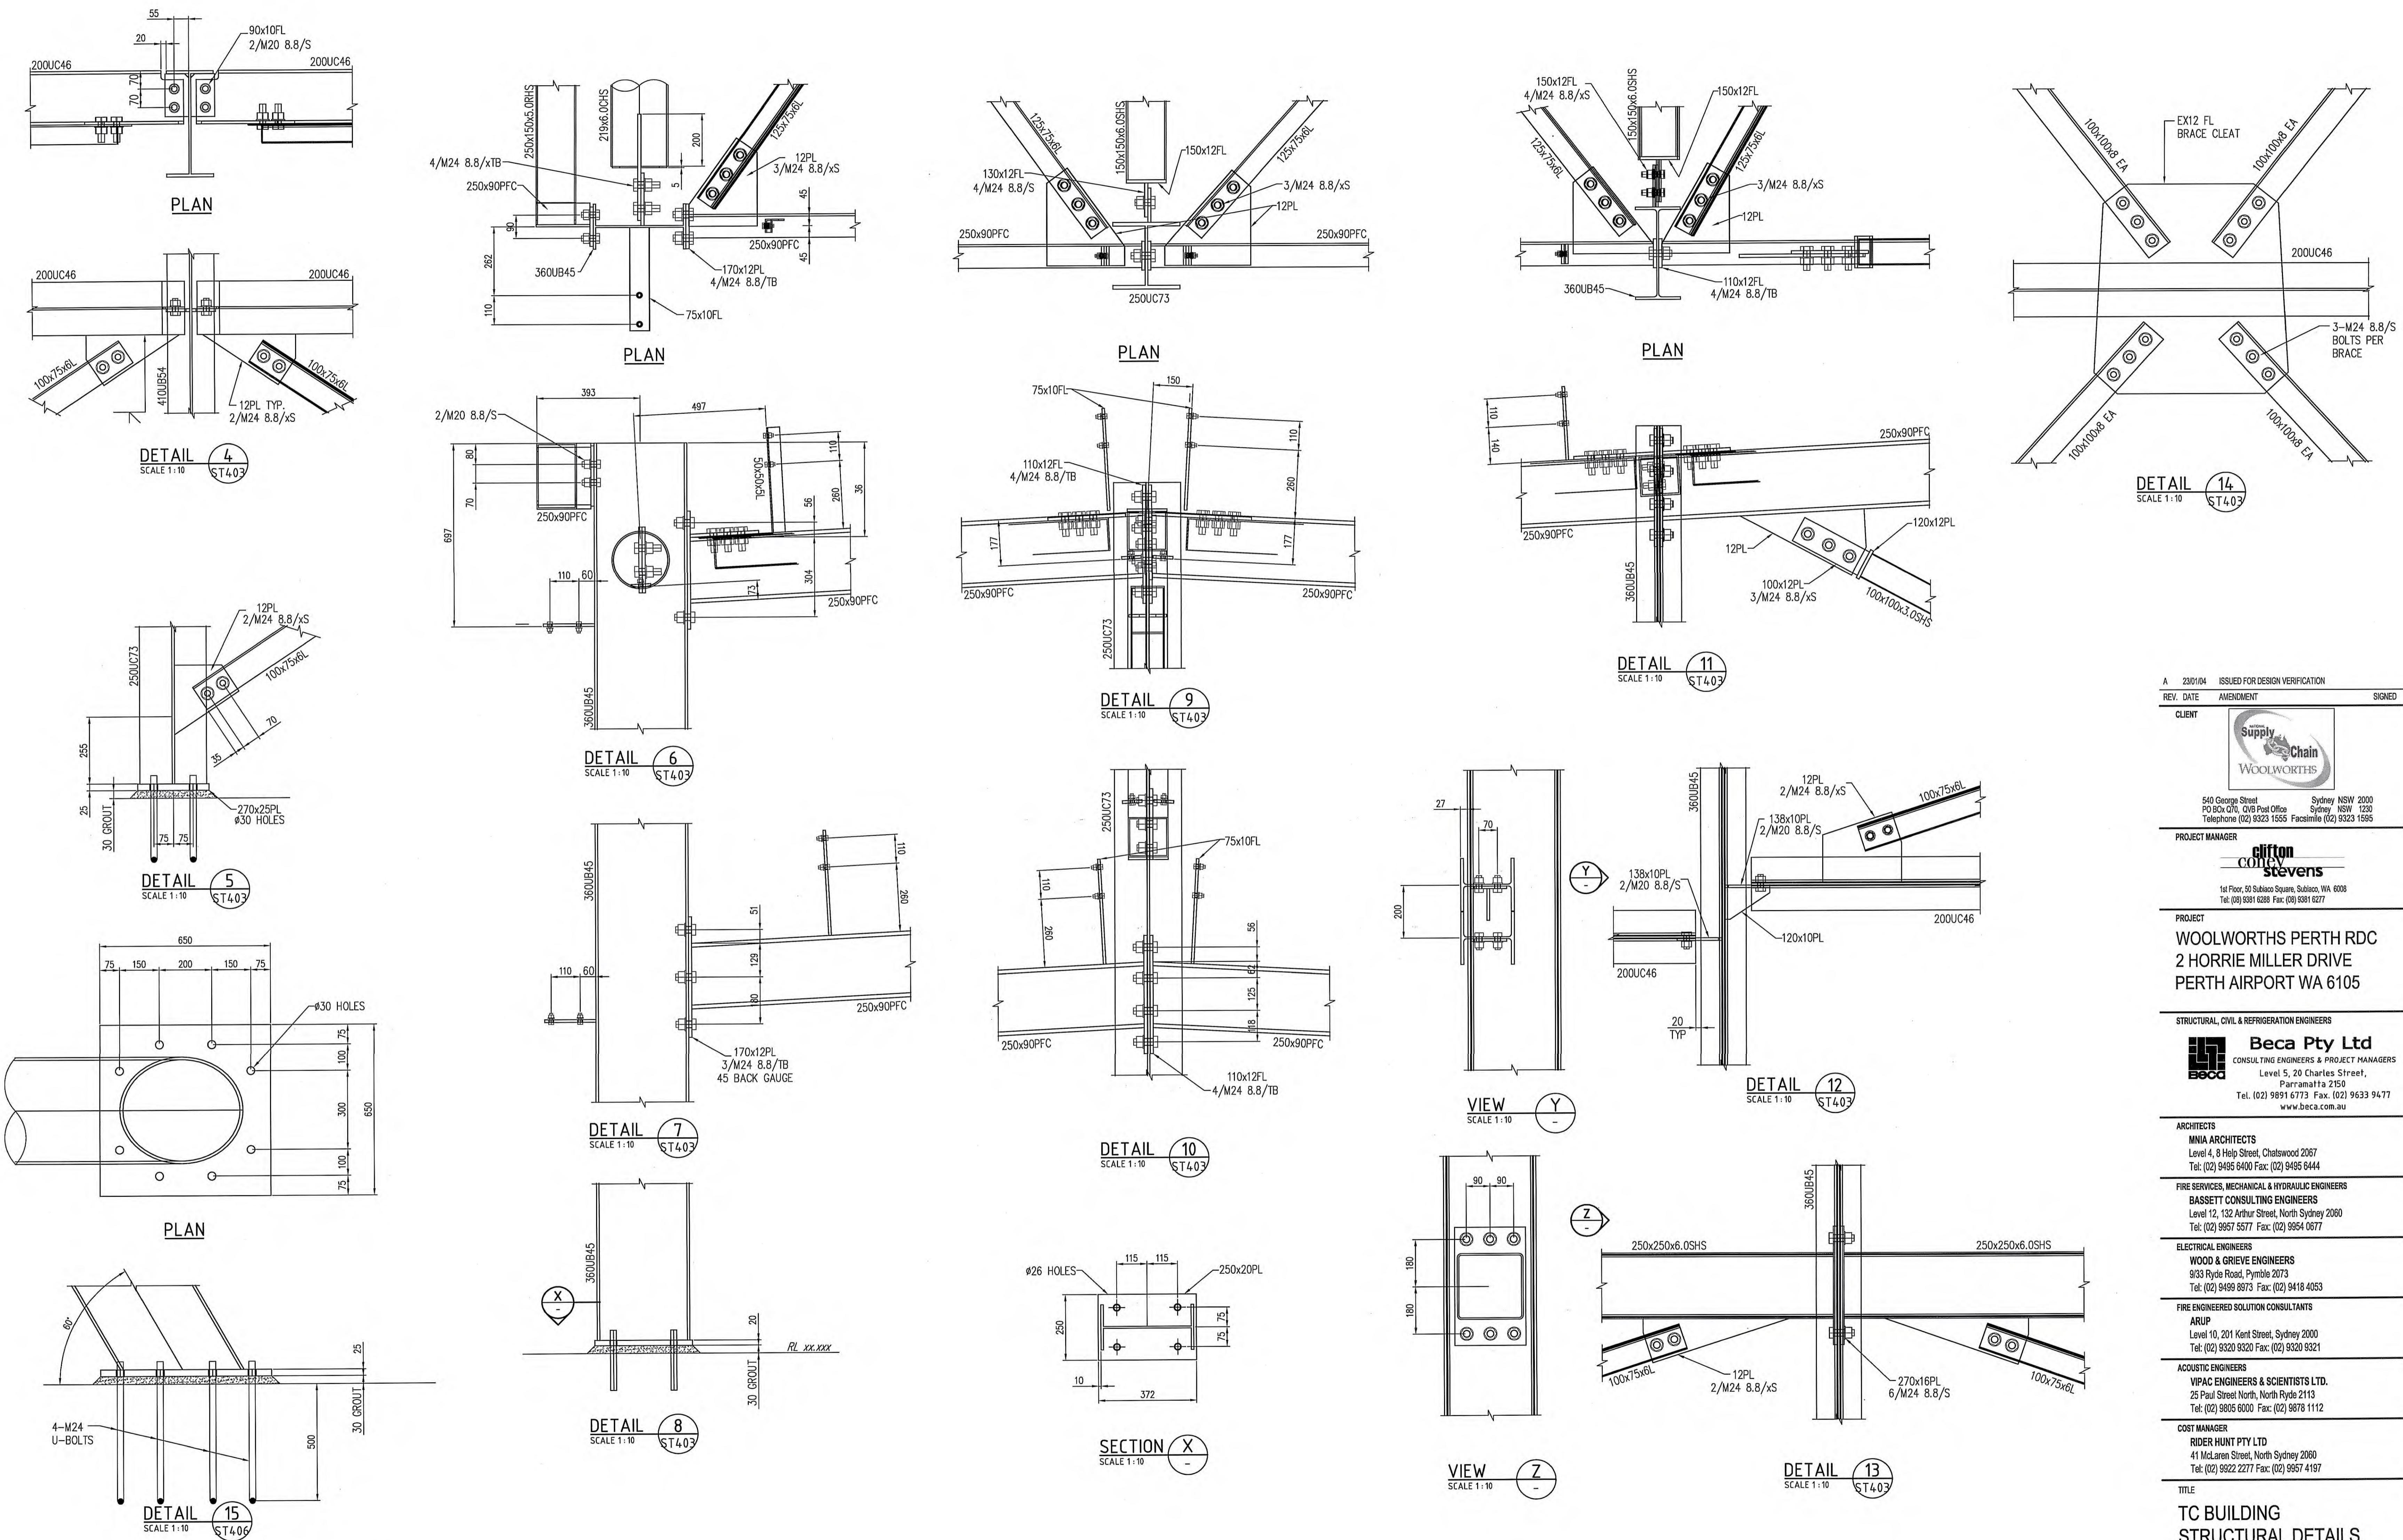

A 23/01/04 ISSUED FOR DESIGN VERIFICATION
REV. DATE AMENDMENT SIGNED
CLIENT

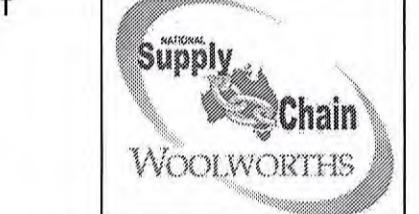

540 George Street Sydney NSW 2000
PO Box Q70, QVB Post Office Sydney NSW 1230
Telephone (02) 9323 1555 Facsimile (02) 9323 1555

PROJECT MANAGER clifton coney stevens

1st Floor, 59 Elizabeth Square, Subiaco, WA 6008
Tel: (08) 9381 6288 Fax: (08) 9381 6277

PROJECT WOOLWORTHS PERTH RDC
2 HORRIE MILLER DRIVE
PERTH AIRPORT WA 6105

STRUCTURAL, CIVIL & REFRIGERATION ENGINEERS

Beca Pty Ltd
CONSULTING ENGINEERS & PROJECT MANAGERS
Level 5, 20 Charles Street, Parramatta 2150
Tel: (02) 8981 6773 Fax: (02) 9633 9477
www.beca.com.au

ARCHITECTS MINA ARCHITECTS

Level 5, 8 Hele Street, Chatswood 2067
Tel: (02) 9495 6400 Fax: (02) 9495 6444

FIRE SERVICES, MECHANICAL & HYDRAULIC ENGINEERS BASSETT CONSULTING ENGINEERS

Level 12, 132 Arthur Street, North Sydney 2060
Tel: (02) 9957 5577 Fax: (02) 9954 0577

ELECTRICAL ENGINEERS WOO & GRIEVES ENGINEERS

9/33 Ryde Road, Rydale 2123
Tel: (02) 9499 8973 Fax: (02) 9418 4053

FIRE ENGINEERED SOLUTION CONSULTANTS ARUP

Level 10, 201 Kent Street, Sydney 2000
Tel: (02) 8320 9320 Fax: (02) 9320 9321

ACOUSTIC ENGINEERS VIPAC ENGINEERS & SCIENTISTS LTD.

25 Paul Street, North Ryde 2123
Tel: (02) 9805 6000 Fax: (02) 9878 1112

COST MANAGER RIDER HUNT PTY LTD

41 McLaren Street, North Sydney 2060
Tel: (02) 9922 2277 Fax: (02) 9957 4197

TITLE TC BUILDING

STRUCTURAL DETAILS
SHEET 2

DATE 07.01.04 PROJECT No. 3172 STATUS ST/DV

SCALE AS 1:10 (B1)


DRAWN

CHECKED


APPROVED

REV. NO.

ST501 A

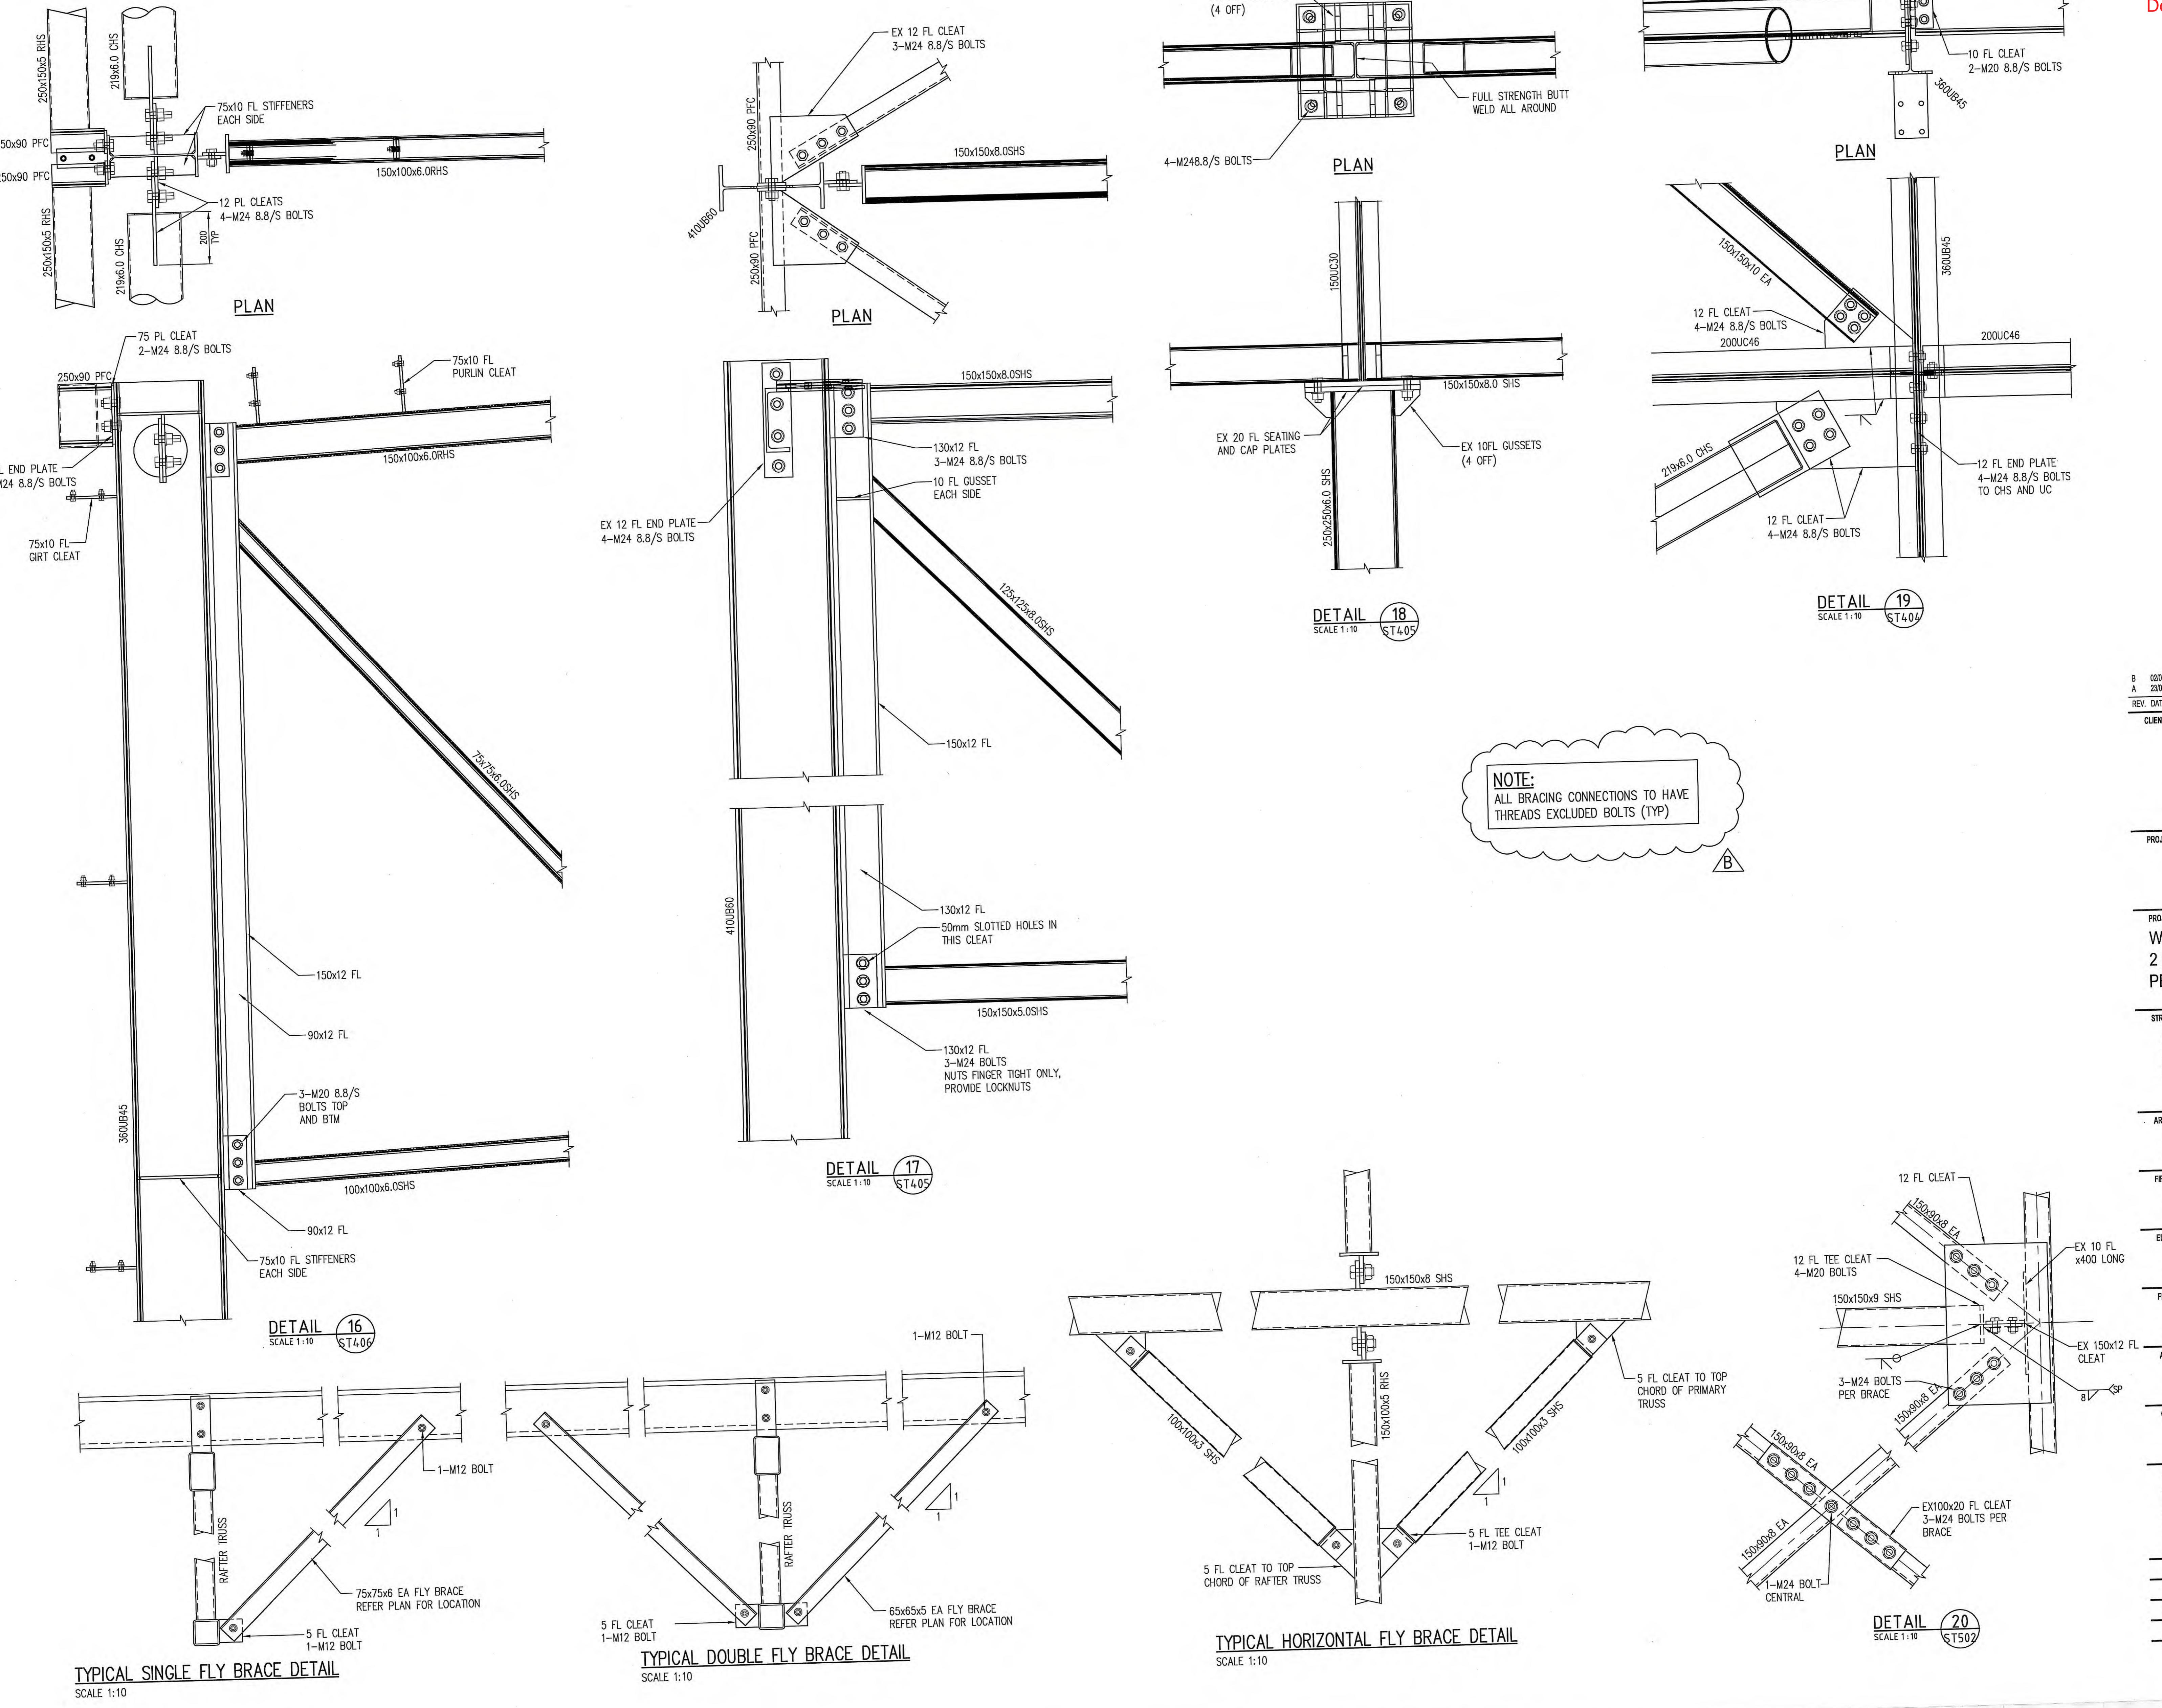

B 02/03/04 MINOR REVISIONS
A 23/01/04 ISSUED FOR DESIGN VERIFICATION
REV. DATE AMENDMENT SIGNED

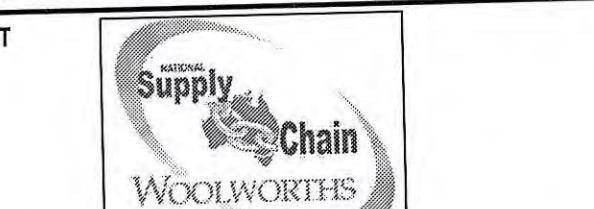

540 George Street Sydney NSW 2000
PO BOX 070, QVB Post Office Sydney NSW 1220
Telephone (02) 9323 1555 Facsimile (02) 9323 1595

PROJECT MANAGER
clifton stevens
1st Floor, 50 Subiaco Square, Subiaco, WA 6008
Tel: (08) 9381 6268 Fax: (08) 9381 6277

PROJECT
WOOLWORTHS PERTH RDC
2 HORRIE MILLER DRIVE
PERTH AIRPORT WA 6105

STRUCTURAL, CIVIL & REFRIGERATION ENGINEERS
Beca Pty Ltd
CONSULTING ENGINEERS & PROJECT MANAGERS
Level 5, 20 Charles Street, Parramatta 2150
Tel: (02) 9891 6773 Fax: (02) 9633 4977
www.beca.com.au

ARCHITECTS
MNA ARCHITECTS
Level 4, 8 Help Street, Chatswood 2067
Tel: (02) 9495 6400 Fax: (02) 9495 6444

FIRE SERVICES, MECHANICAL & HYDRAULIC ENGINEERS
BASSETT CONSULTING ENGINEERS
Level 12, 132 Arthur Street, North Sydney 2060
Tel: (02) 9957 5577 Fax: (02) 9954 0677








ELECTRICAL ENGINEERS
WOOD & GRIEVES ENGINEERS
933 Ryde Road, Pymble 2073
Tel: (02) 9499 8973 Fax: (02) 9418 4053

FIRE ENGINEERED SOLUTION CONSULTANTS
ARUP
Level 10, 201 Kent Street, Sydney 2000
Tel: (02) 9320 9320 Fax: (02) 9320 9321

ACOUSTIC ENGINEERS
VIPAC ENGINEERS & SCIENTISTS LTD.
25 Paul Street 6000 Fax: (02) 9878 1112


COST MANAGER
RIDER HUNT PTY LTD
41 McLaren Street, North Sydney 2060
Tel: (02) 9922 2277 Fax: (02) 9957 4197

TC BUILDING STRUCTURAL SECTIONS SHEET 3
DATE 07.01.04 PROJECT No. 3172 STATUS ST/DV
SCALE AS 1:10 (B1)
DRAWN
CHECKED
APPROVED DWG. No. ST502 REV. No. B

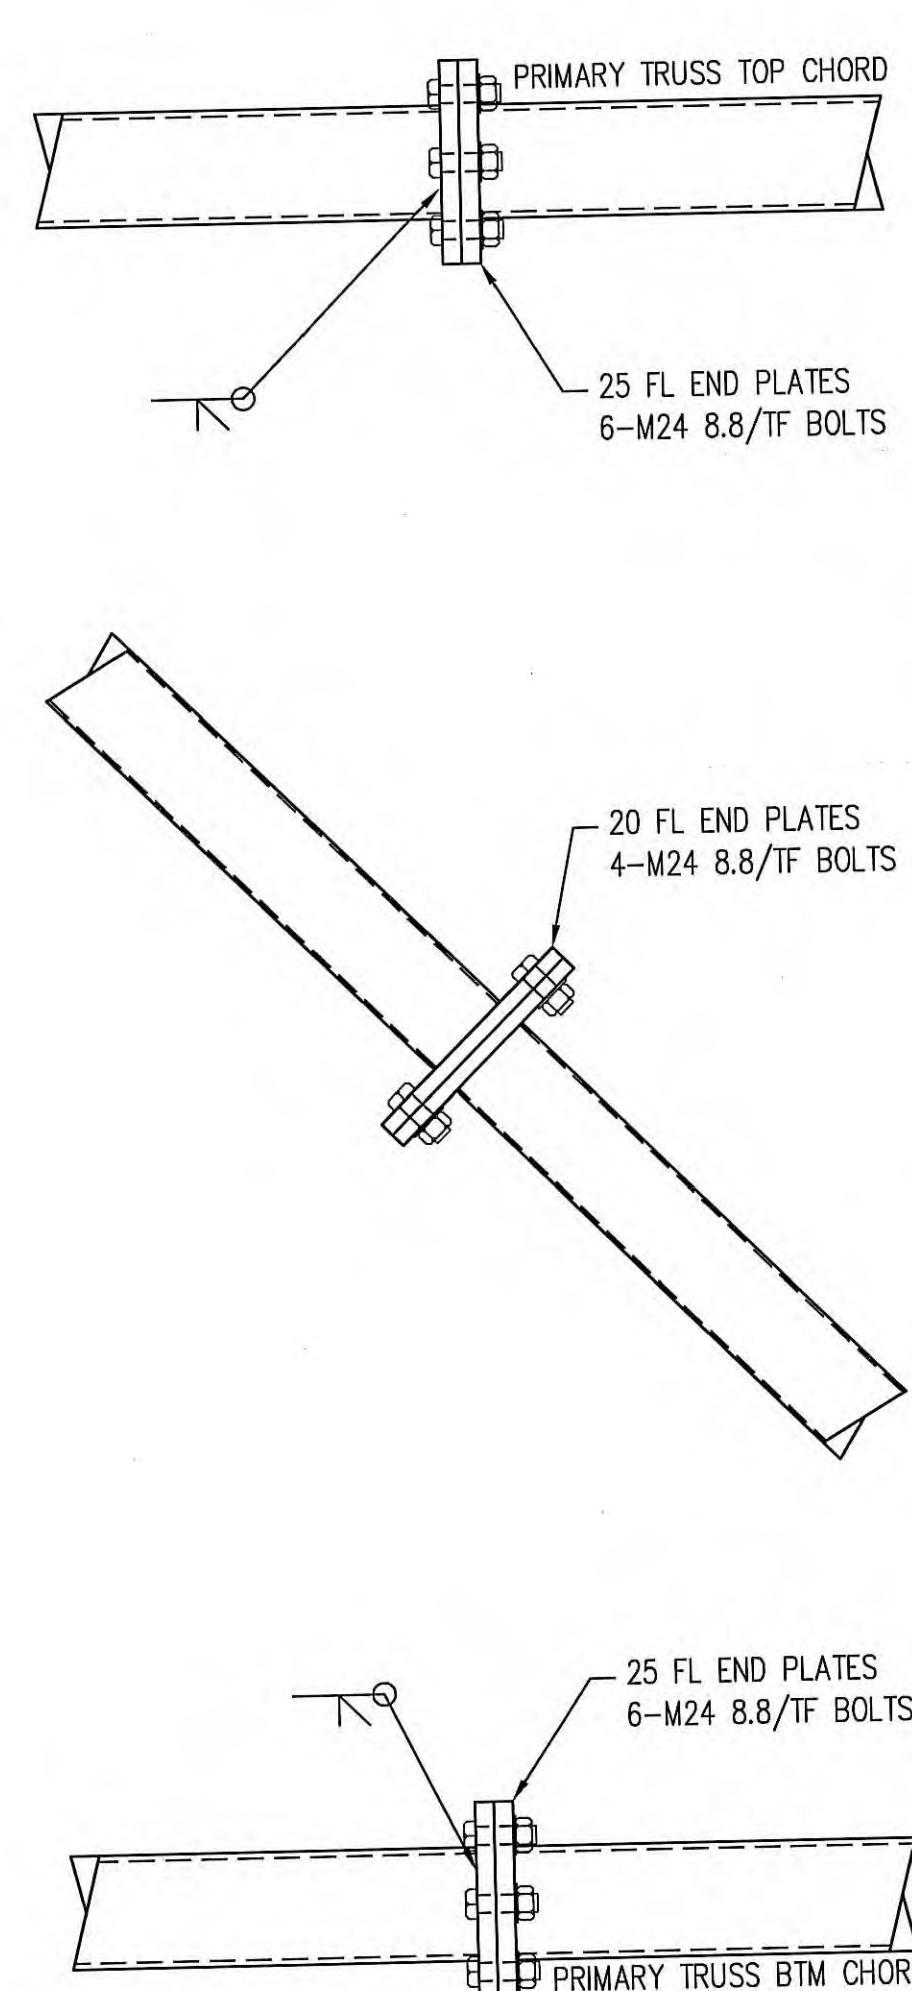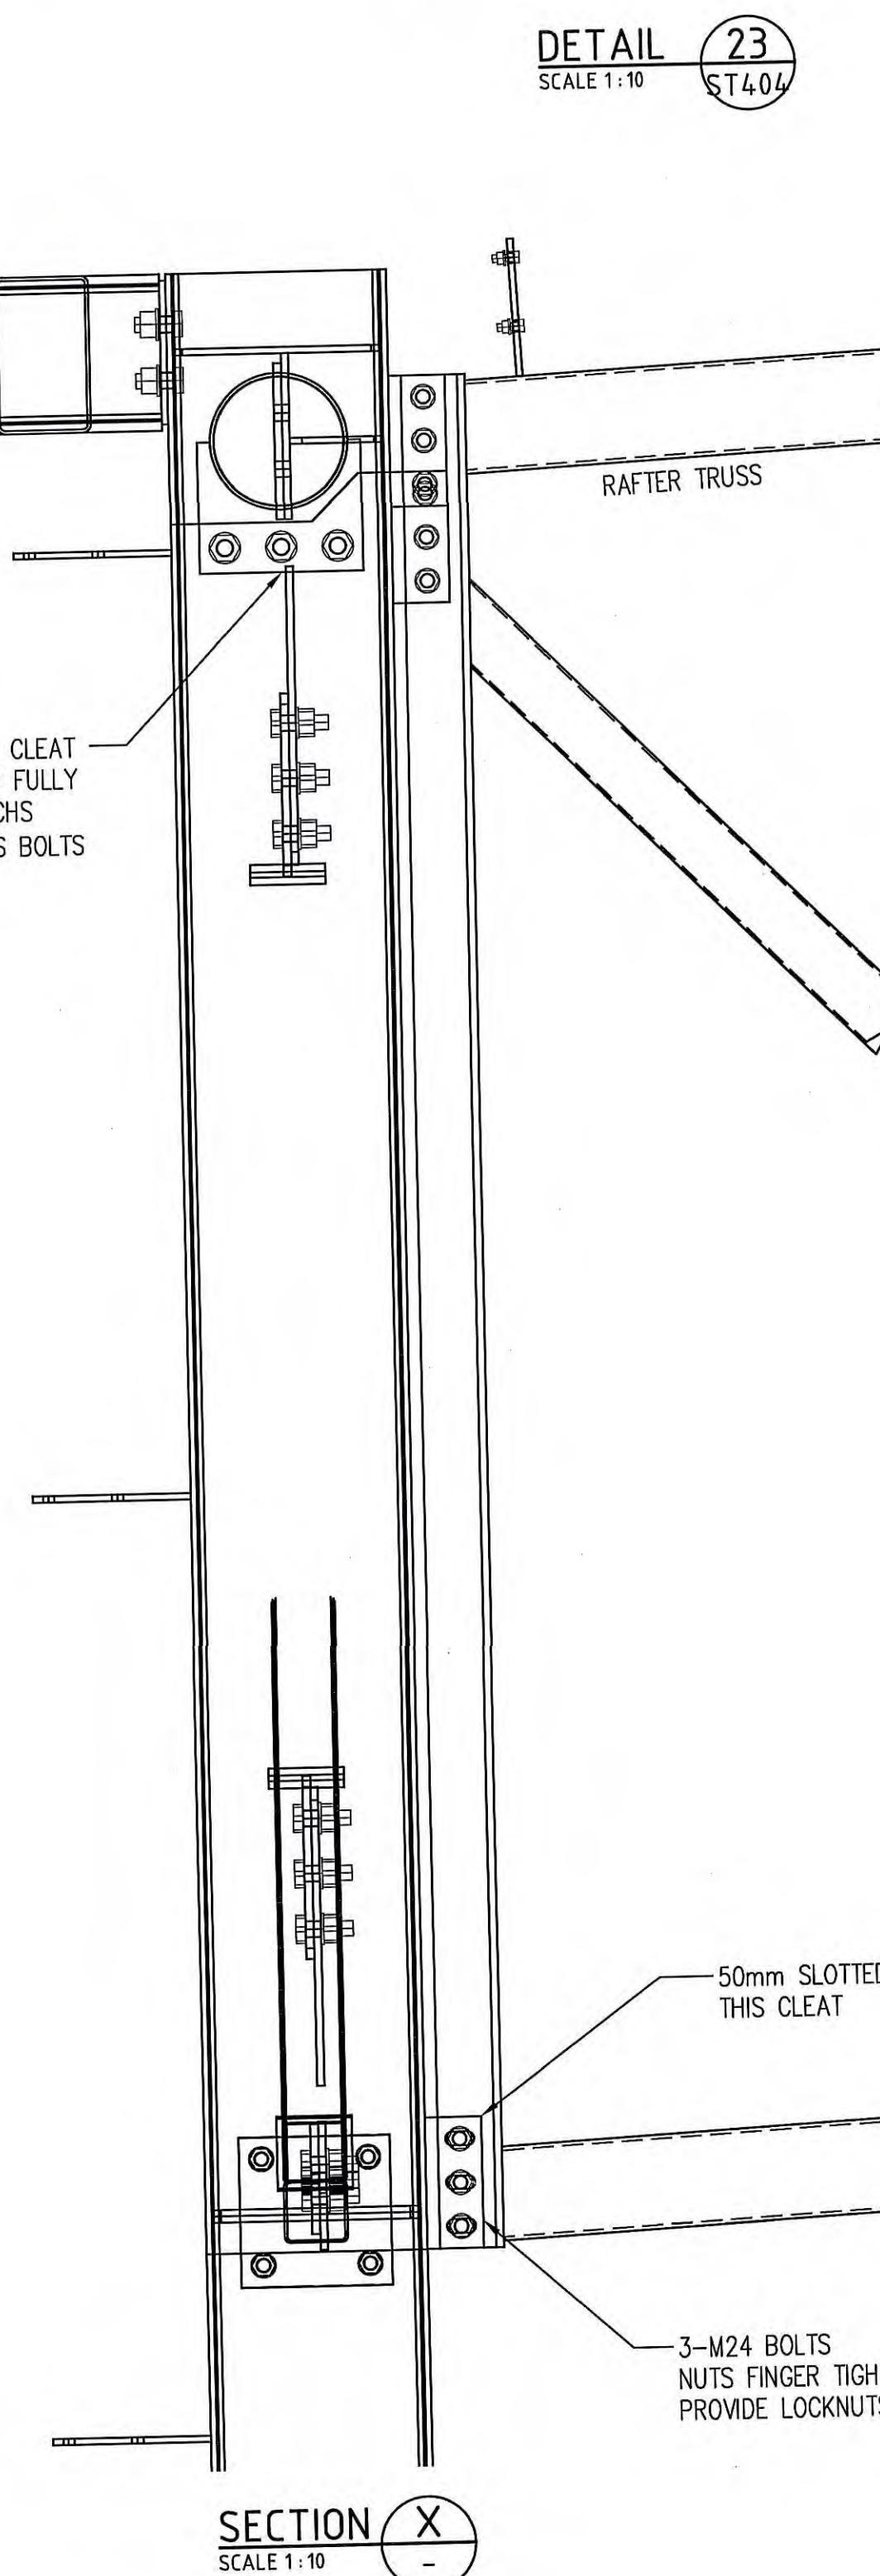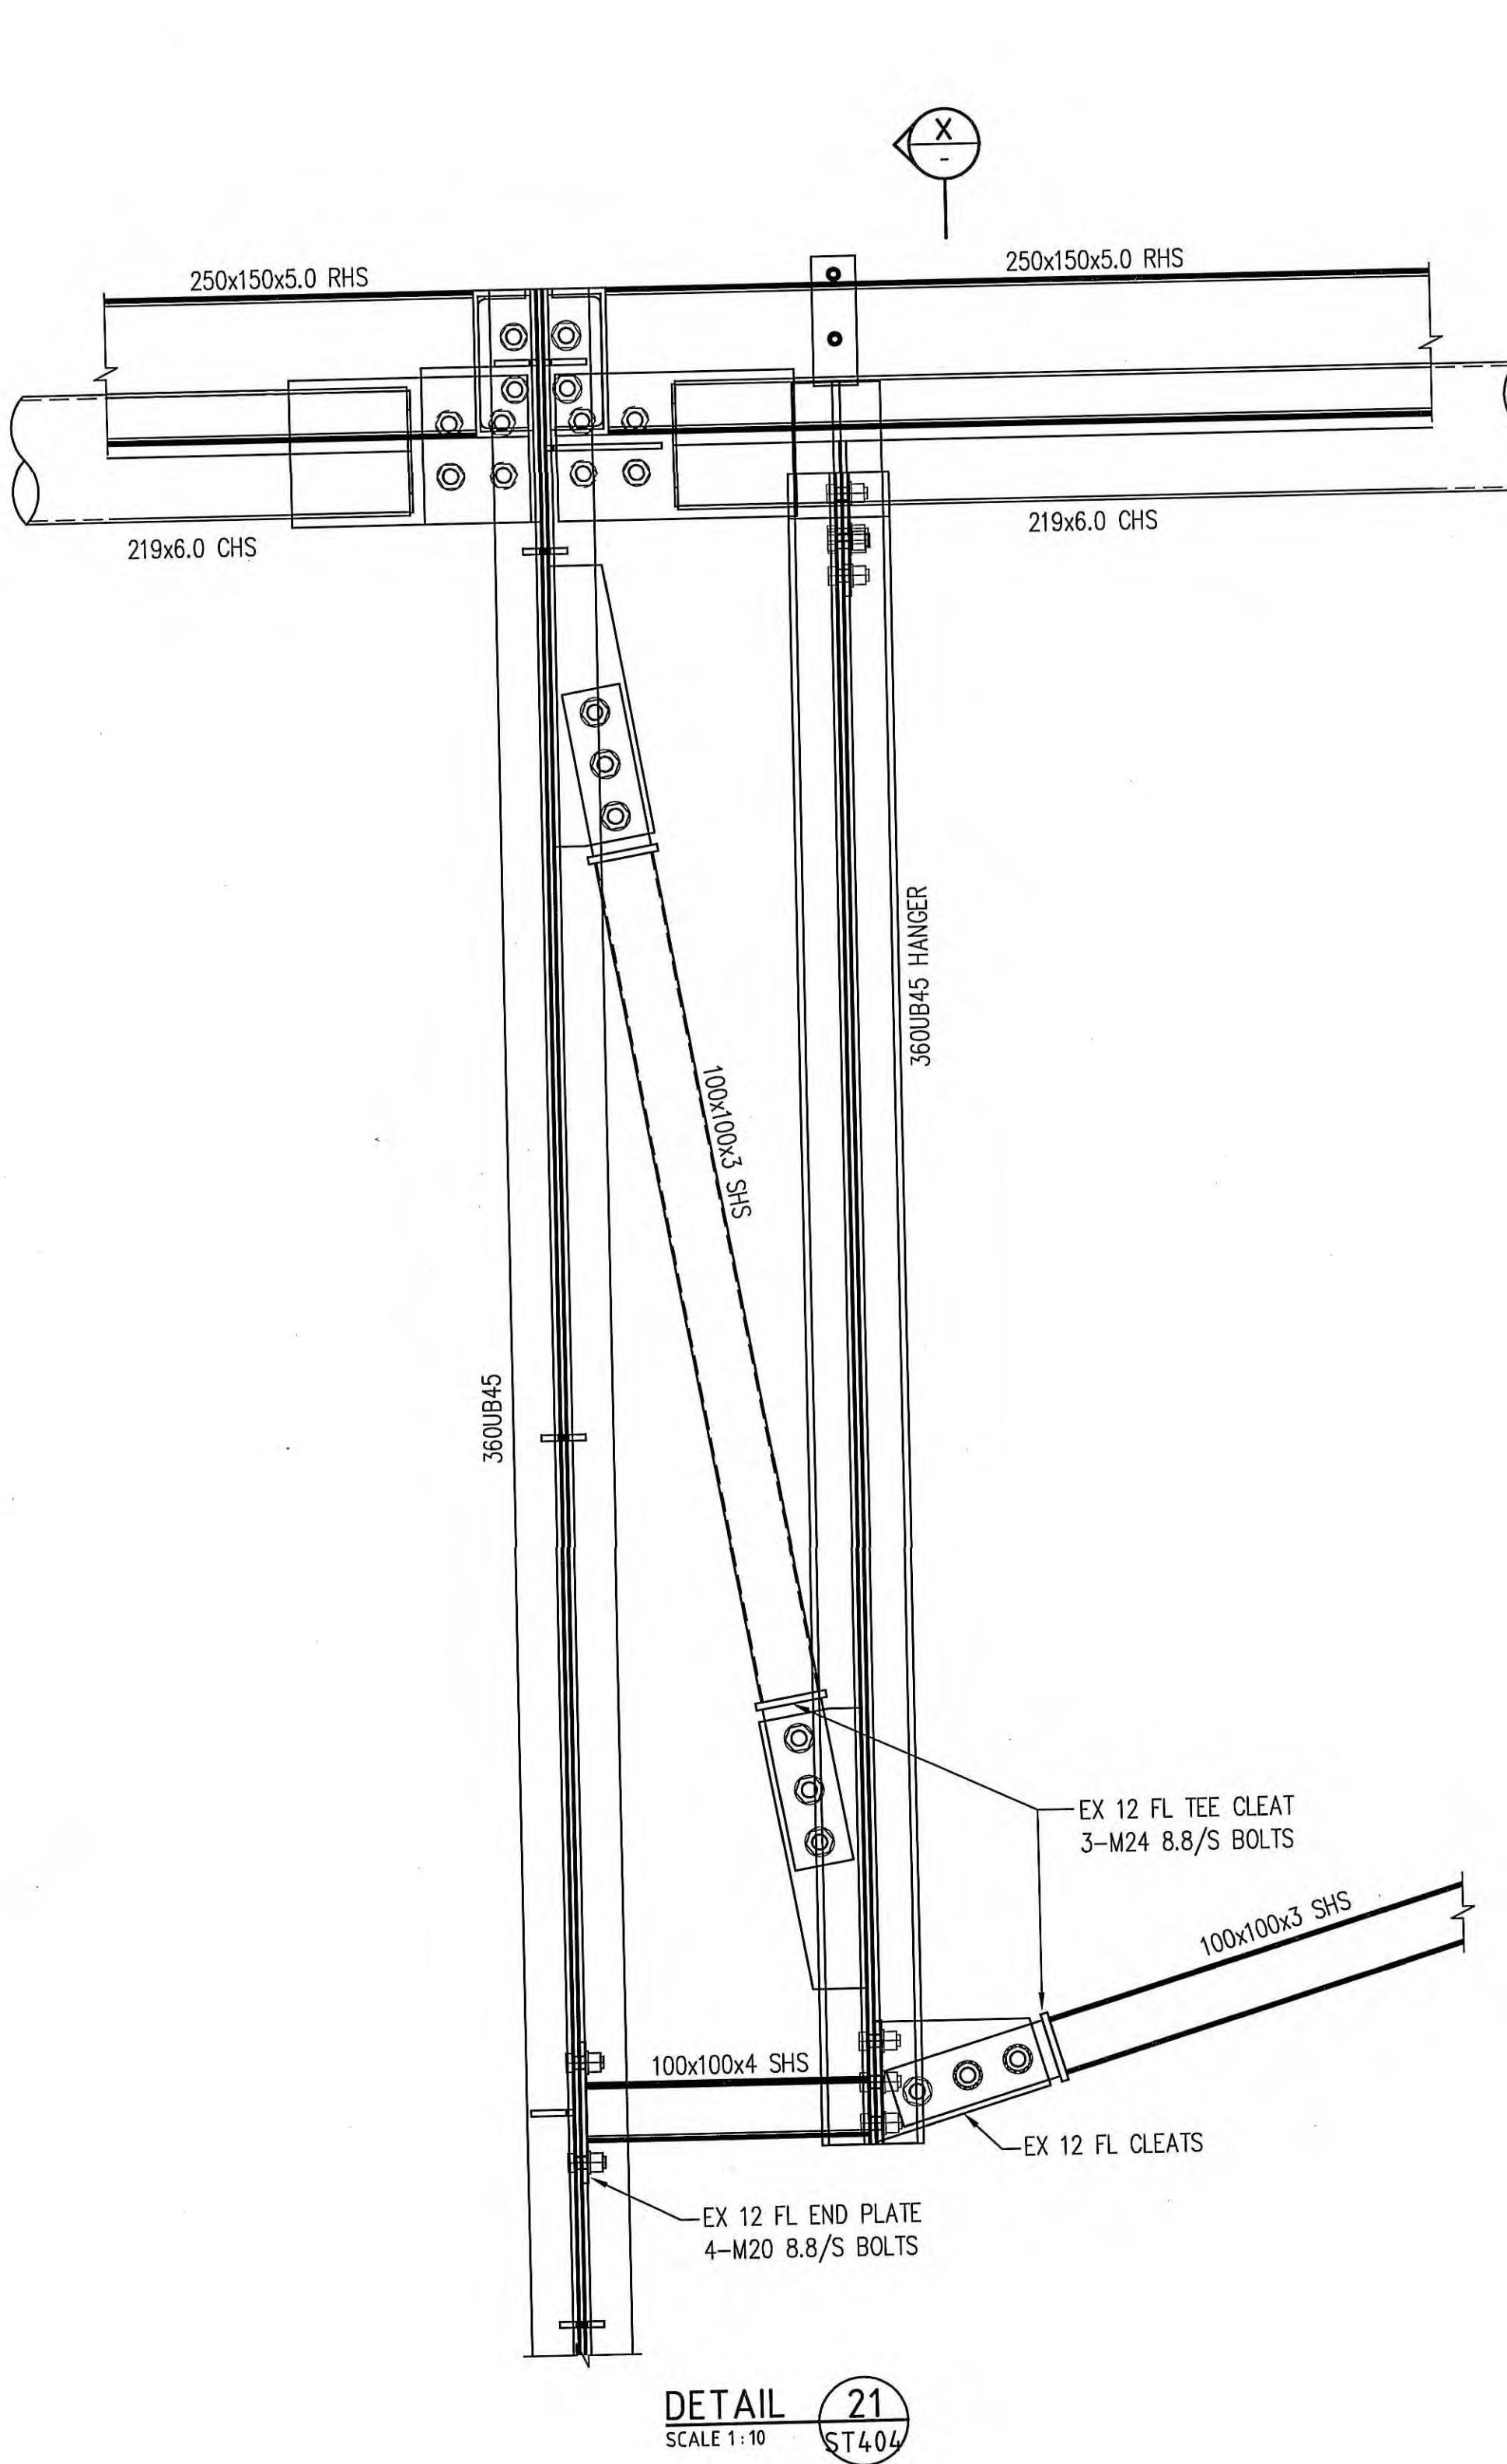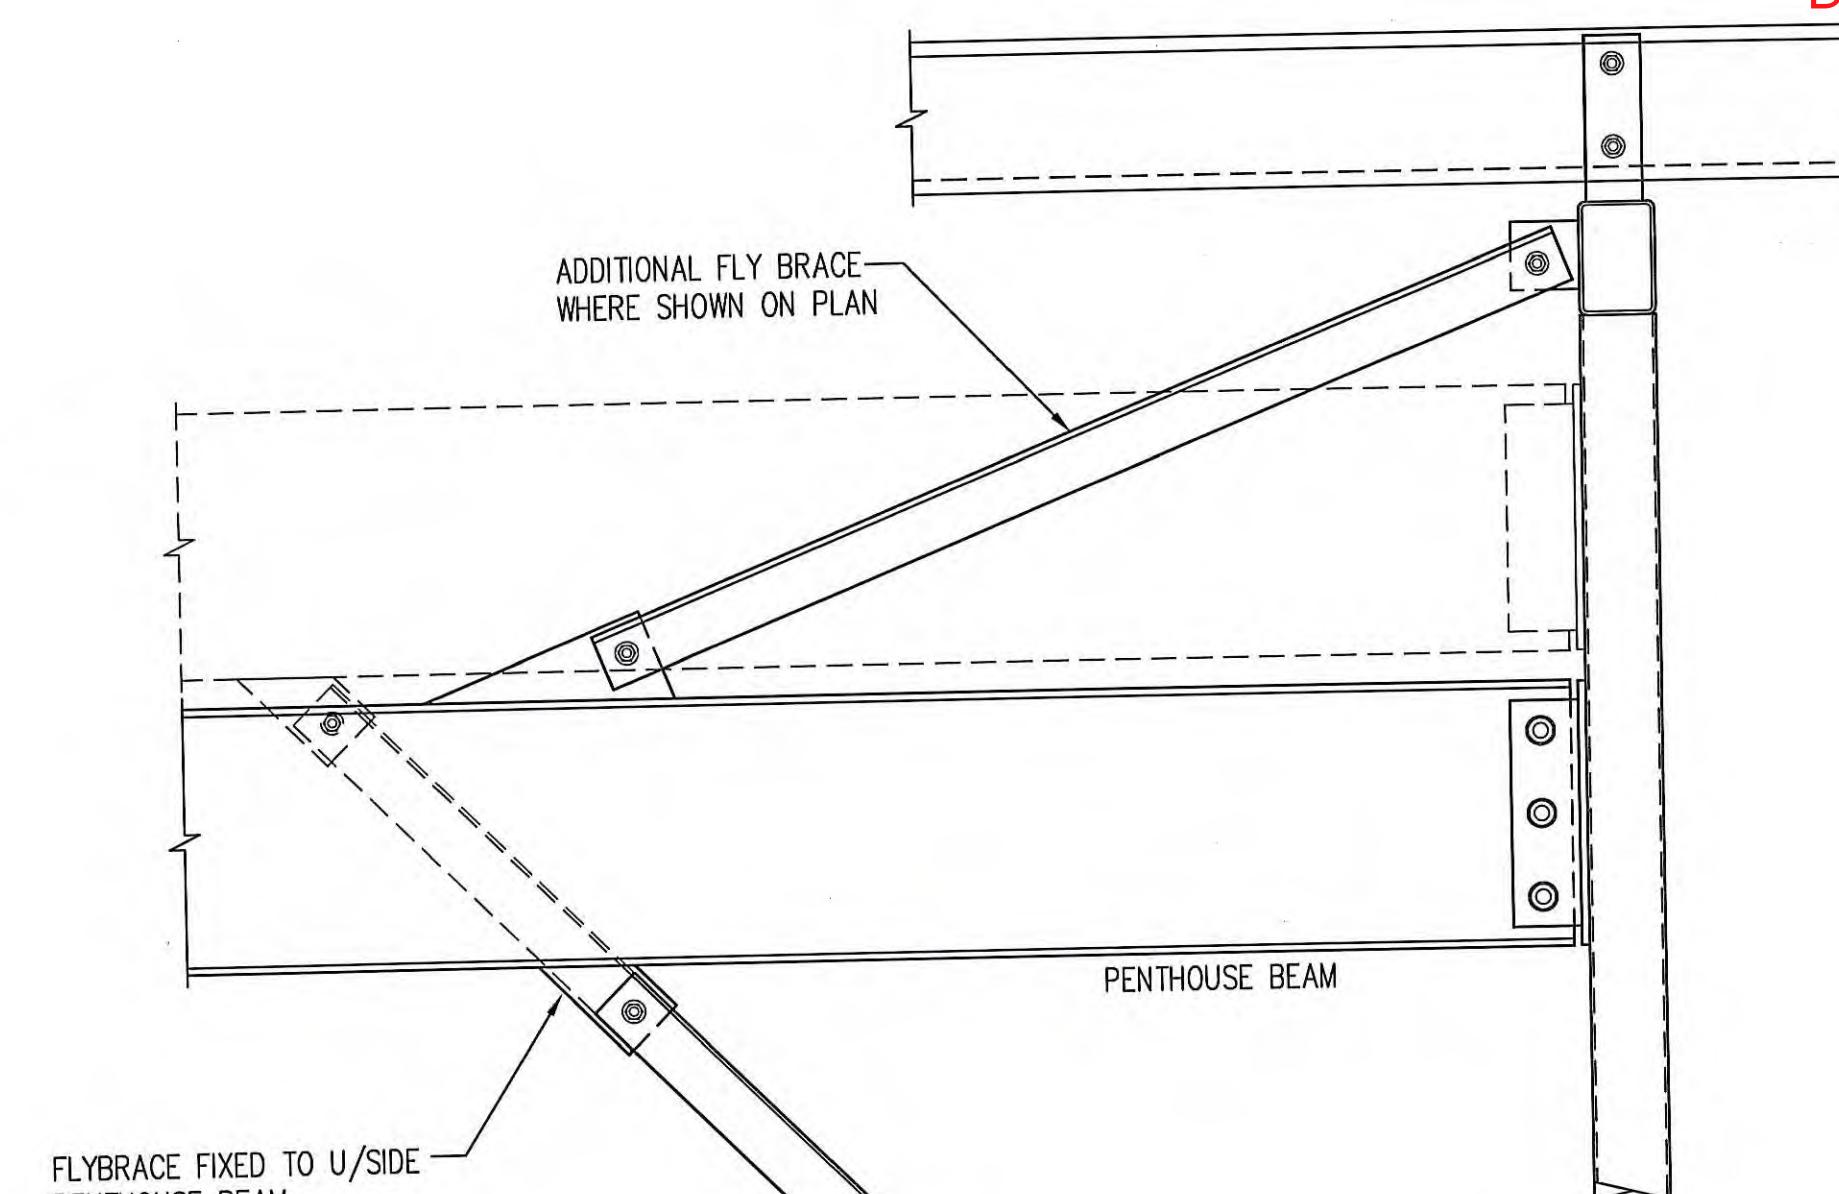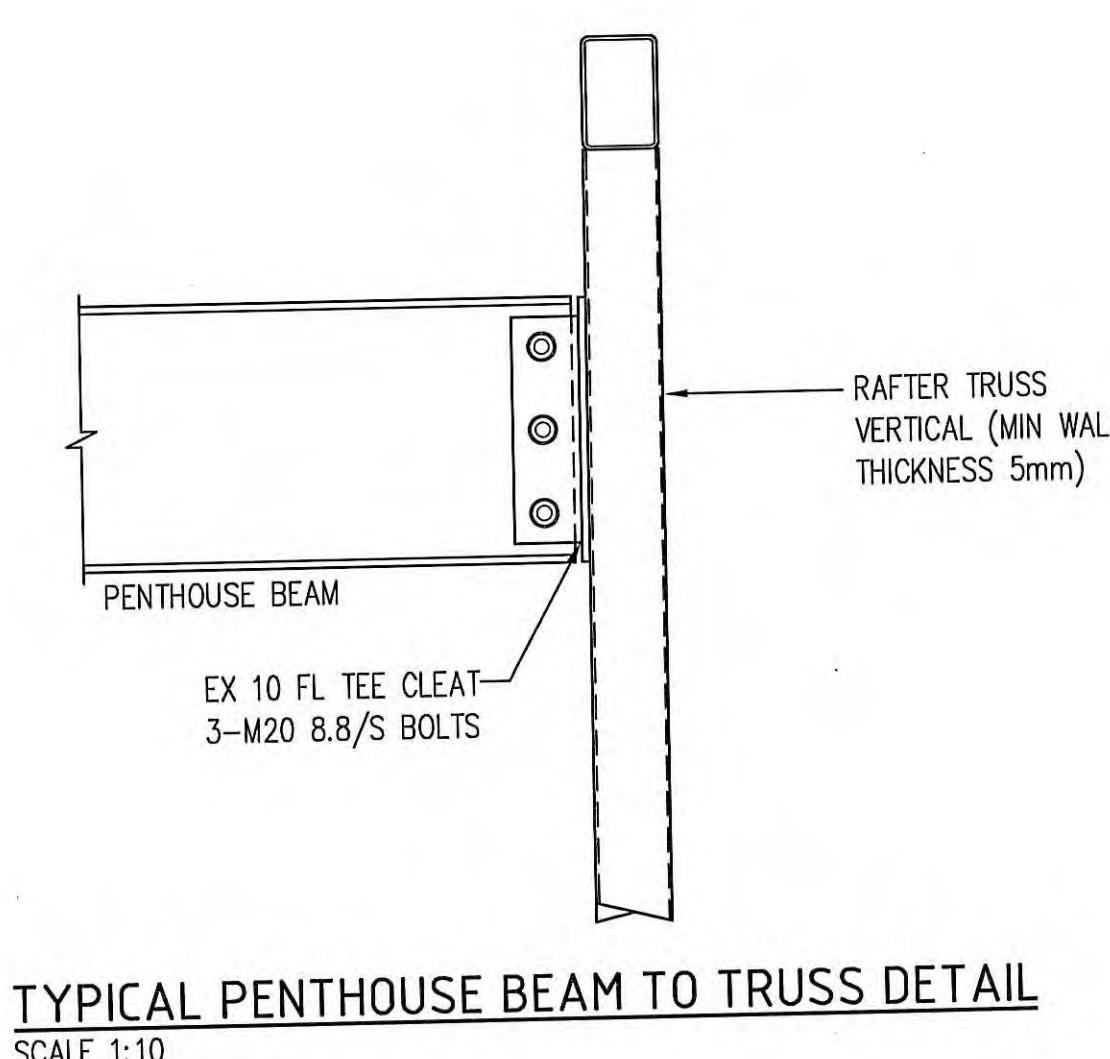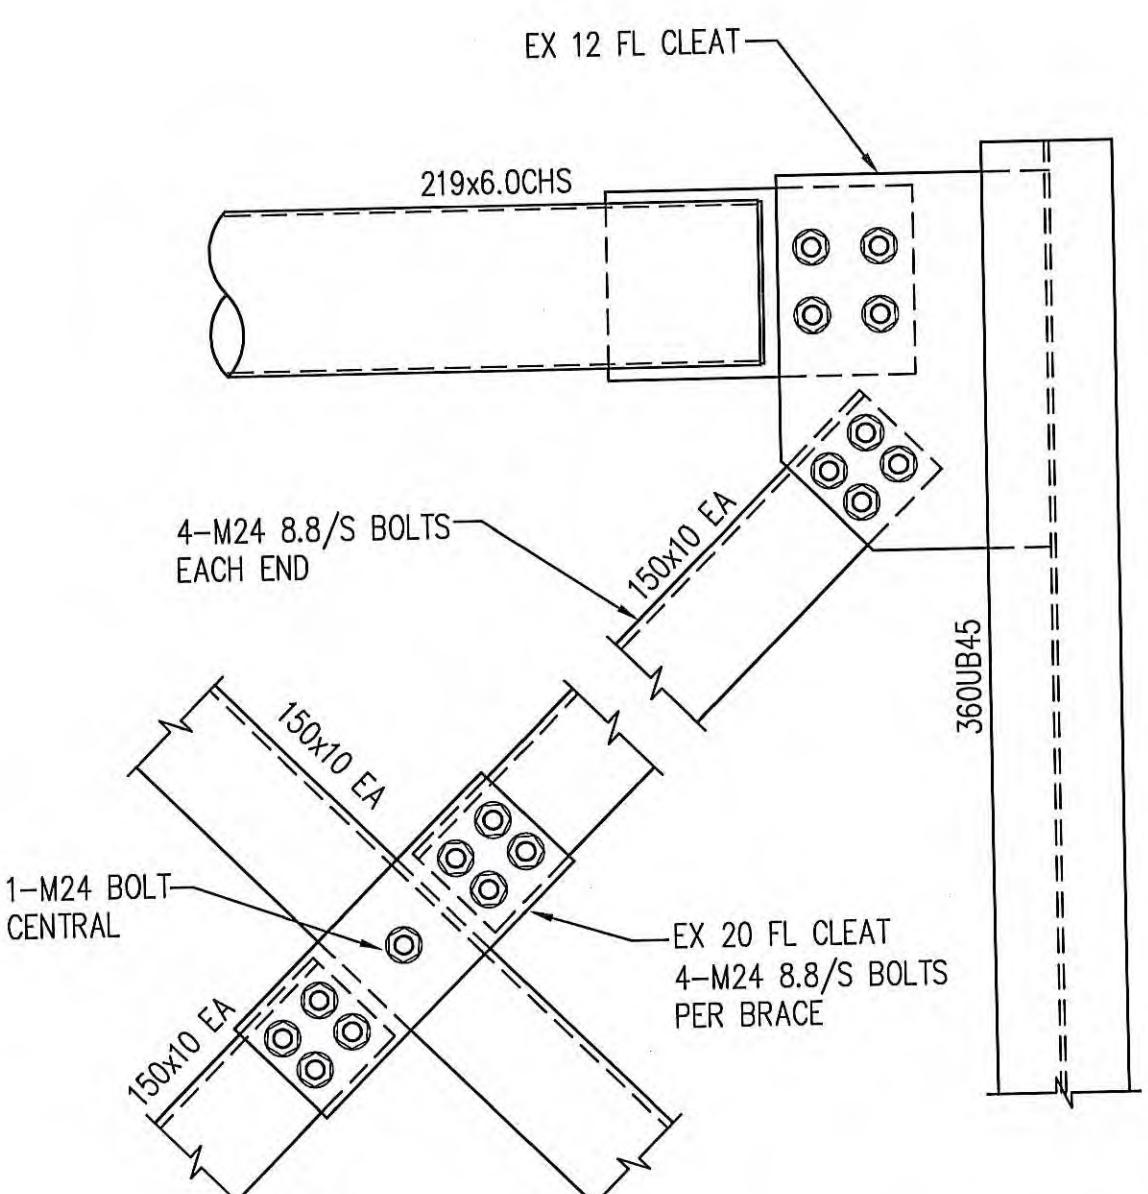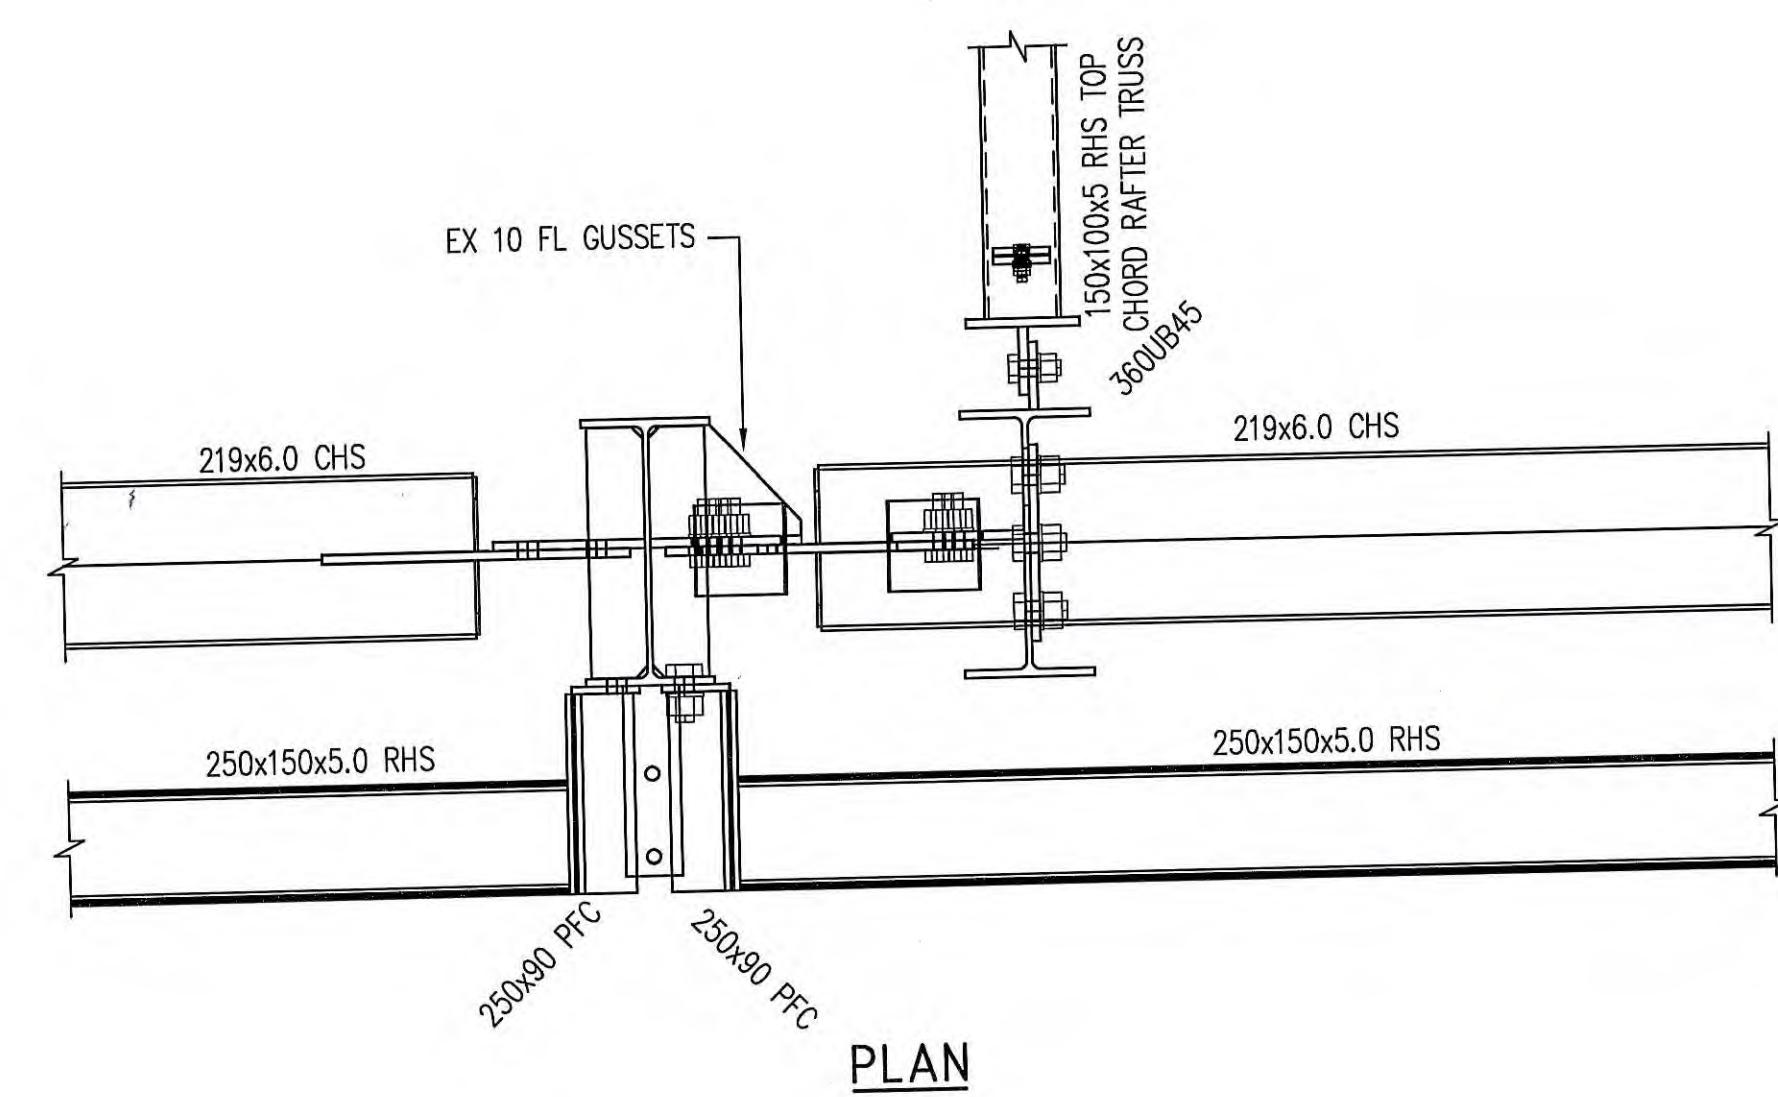

NOTE:
THREADS EXCLUDED BOLTS FOR
TRUSS SPLICE CONNECTIONS (TYP)

B

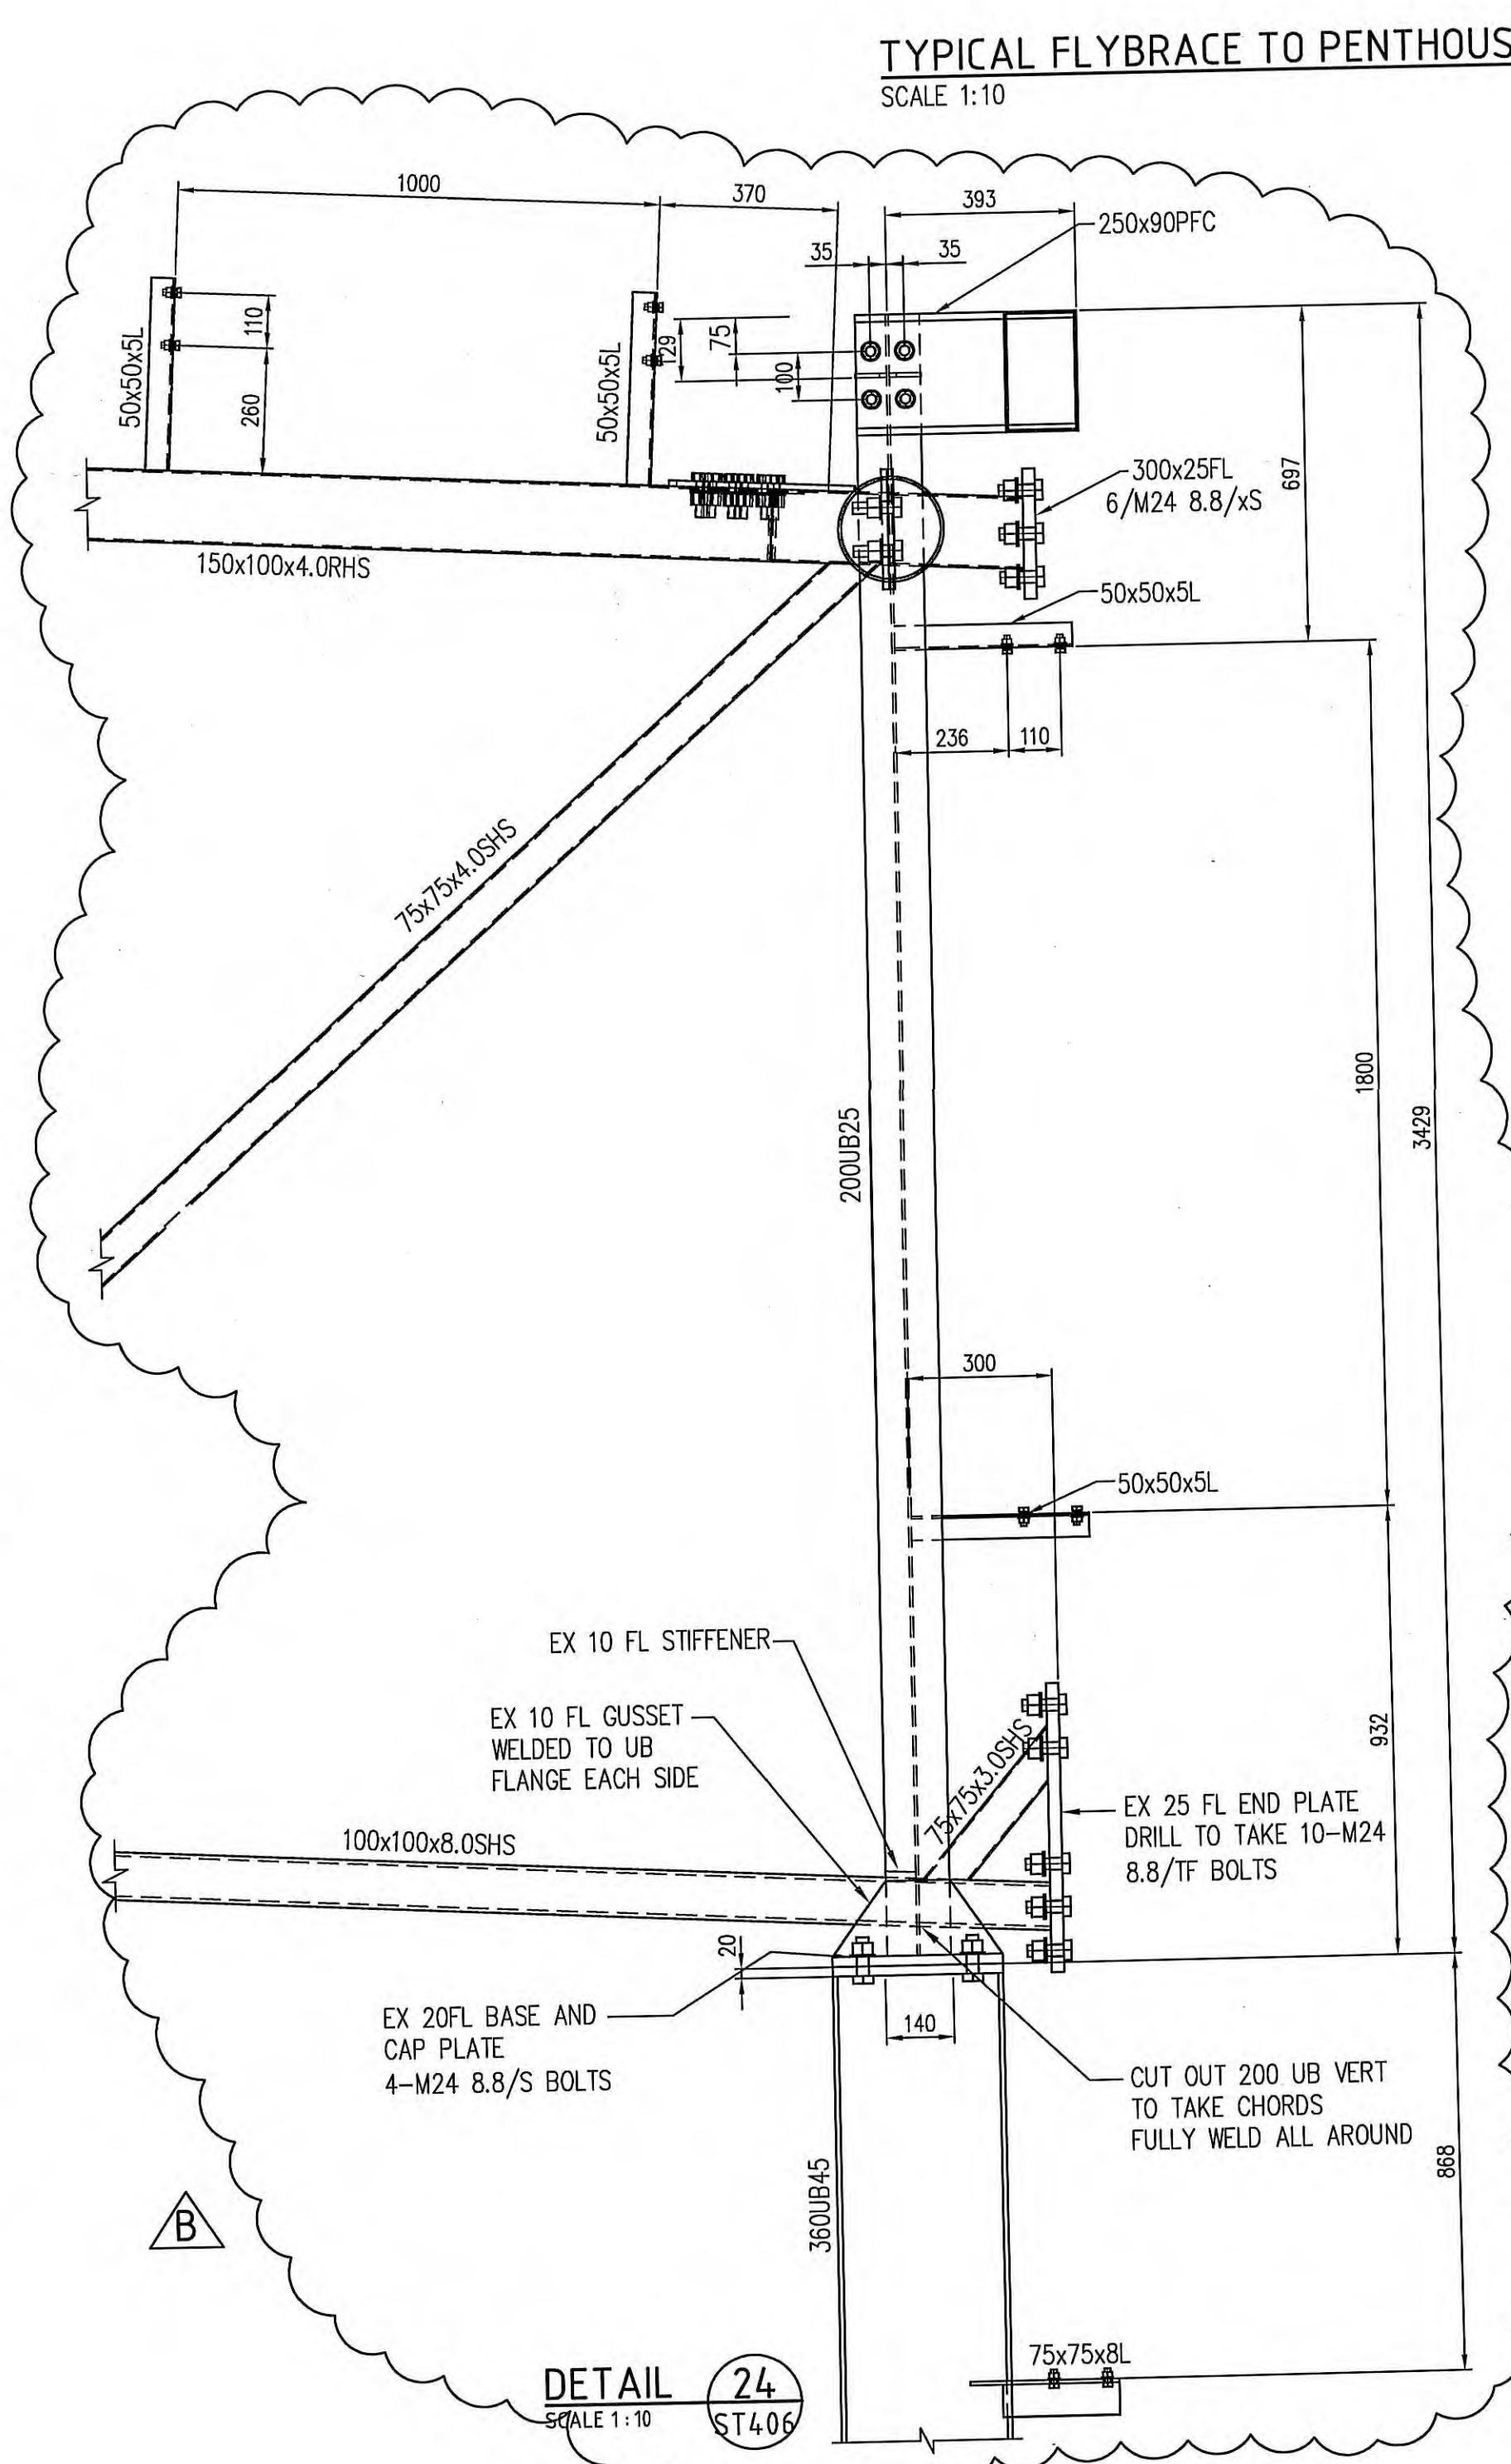

B 03/02/04 MINOR REVISIONS ISSUED FOR DESIGN VERIFICATION
A 23/01/04
REV. DATE AMENDMENT SIGNED
CLIENT

540 George Street Sydney NSW 2000
PO Box 200, GPO Post Office Sydney NSW 1230
Telephone (02) 9323 1555 Facsimile (02) 9323 1995

PROJECT MANAGER
 Clifton Stevens

1st Floor, 50 Subiaco Square, Subiaco, WA 6008
Tel: (08) 9381 6288 Fax: (08) 9381 6277

PROJECT
WOOLWORTHS PERTH RDC
2 HORRIE MILLER DRIVE
PERTH AIRPORT WA 6105

STRUCTURAL, CIVIL & REFRIGERATION ENGINEERS
Beca Pty Ltd
CONSULTING ENGINEERS & PROJECT MANAGERS
Level 5, 20 Charles Street,
Paramatta 2150
Tel: (02) 9891 6773 Fax: (02) 9833 9477
www.beca.com.au

ARCHITECTS
MNA ARCHITECTS
Level 4, 8 Help Street, Chatswood 2067
Tel: (02) 9495 6400 Fax: (02) 9495 6444

FIRE SERVICES, MECHANICAL & HYDRAULIC ENGINEERS
BASSETT CONSULTING ENGINEERS
Level 12, 132 Arthur Street, North Sydney 2060
Tel: (02) 9957 5577 Fax: (02) 9954 0677

ELECTRICAL ENGINEERS
WOOD & GRIEVE ENGINEERS
933 Ryde Road, Pymble 2073
Tel: (02) 9499 6973 Fax: (02) 9418 4053

FIRE ENGINEERED SOLUTION CONSULTANTS
ARUP
Level 10, 201 Kent Street, Sydney 2000
Tel: (02) 9320 9320 Fax: (02) 9320 9321

ACOUSTIC ENGINEERS
VIPAC ENGINEERS & SCIENTISTS LTD.
25 Paul Street North, North Ryde 2113
Tel: (02) 8865 6000 Fax: (02) 9878 1112

COST MANAGER
RIDER HUNT PTY LTD
41 McLaren Street, North Sydney 2060
Tel: (02) 9922 2277 Fax: (02) 9957 4197

TC BUILDING
STRUCTURAL SECTIONS
SHEET 3

DATE 07.01.04 PROJECT NO 3172 STATUS ST/DV
SCALE AS 1:10 (B1)
DRAWN
CHECKED APPROVED DWG NO. ST503
REV. NO. B